

# COUNTY GOVERNMENT OF KISUMU



# KISUMU WATER AND SANITATION COMPANY LIMITED- KIWASCO



# **WATER SECTOR TRUST FUND**


# DEVELOPMENT OF THE WATER AND SANITATION SECTOR

Consulting Services to Develop Bankable Water and Sewerage Proposals for Water Service Providers for Commercial Financing: **Phase IV Lot2** 

KISUMU WATER SUPPLY IMPROVEMENTS
AID ON DELIVERY- AOD PROJECT

Volume 3

**BOOK OF DRAWINGS** 

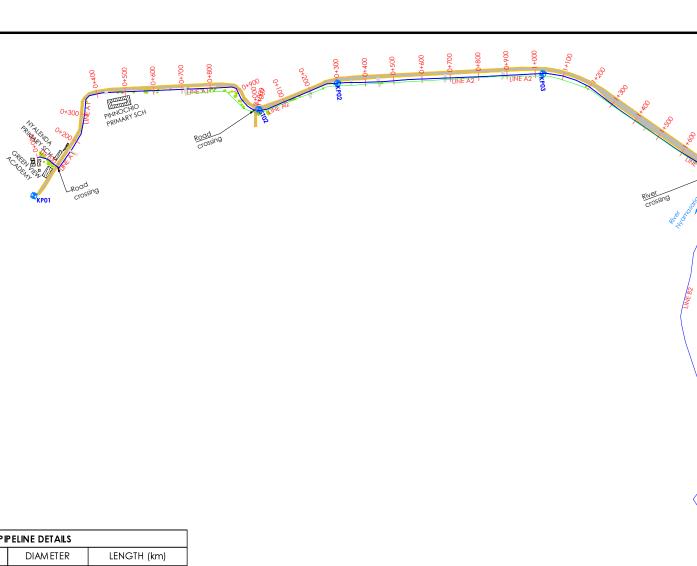

PIPELINE DETAILS				
LINE	MATERIAL	DIAMETER	LENGTH (km)	
A-1	HDPE	200	1.01	
A-2	HDPE	180	2.99	
A-3	HDPE	160	0.93	
B-1	HDPE	110	0.1	
B-2	HDPE	63	1.25	
B-3	HDPE	50	0.42	
C-1	HDPE	90	0.2	
C-2	HDPE	90	0.77	
C-3	HDPE	63	0.56	
D-1	HDPE	75	0.11	
D-2	HDPE	<i>7</i> 5	0.45	
E-1	HDPE	90	0.11	
E-2	HDPE	90	0.74	
E-3	HDPE	63	0.76	
E-4	HDPE	63	0.37	
F-1	HDPE	63	0.11	
F-2	HDPE	63	0.49	
G-1	HDPE	110	0.44	
G-2	HDPE	63	1.41	
G-3	HDPE	50	0.54	

BENCHMARKS				
NAME	N	E	ELEV	CODE
KP01	9988014.387	696643.6651	1148.089	CONTROL
KP02	9988025.376	697785.3951	1140.344	CONTROL
ST02	9988032.803	697492.7081	1140.793	CONTROL
KP03	9987811.971	698478.6781	1141.751	CONTROL
KP04	9987252.905	698978.9041	1143.405	CONTROL
KP05	9986584.108	699421.6251	1141.769	CONTROL
KS3	9986106.876	699563.2311	1140.267	CONTROL
KP06	9985575.154	699722.1781	1141.773	CONTROL
KP07	9985329.769	699794.6091	1140.155	CONTROL

- VERTICAL EXAGGERATION IN PROFILE IS 10 TIMES THE HORIZONTAL SCALE.
- THIS DRAWING TO BE READ WITH ALL RELEVANT LAYOUTS PLAN AND STANDARD DRAWINGS
- 3. PIPE ROUTE TO BE ALIGNED TO MATCH THE FINAL WAYLEAVE

## LEGEND:

PROPOSED WATER PIPE

KENHA BOUNDARY

NON RETURN VALVE (NRV)

PRESSURE REDUCING VALVE (PRV)

ISOLATING VALVE

AIR VALVE (AV)

WASHOUT (WO)

ZONAL METER

FIRE HYDRANT (FH) BENCH MARK (BM)

HGL HYDRAULIC GRADE LINE

TREE

BUILDING



KISUMU WATER AND SANITATION COMPANY



KFW

KISUMU WATER SUPPLY
IMPROVEMENT AID ON DELIVERYAOD PROJECT

DETAILED DESIGN


PLAN AND PROFILE

GENERAL LAYOUT

SCALE: A3 SIZE: SHEET NO: 1 OF 1 KSM/DS/GL/01



LAYOUT PLAN SCALE 1:1000

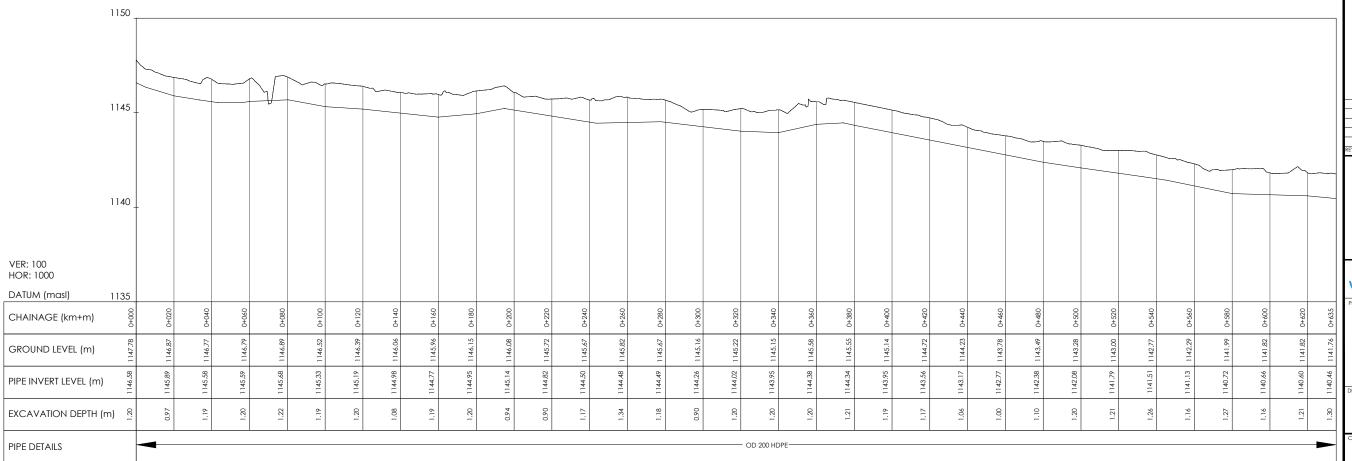

A1 - (1)-LONGITUDINAL PROFILE

SPECIAL DETAILS

# NOTES:

- VERTICAL EXAGGERATION IN PROFILE IS 10 TIMES THE HORIZONTAL SCALE.
- THIS DRAWING TO BE READ WITH ALL RELEVANT LAYOUTS PLAN AND STANDARD DRAWINGS
- PIPE ROUTE TO BE ALIGNED TO MATCH THE FINAL WAYLEAVE

#### LEGEND:

PROPOSED WATER PIPE

KENHA BOUNDARY

NON RETURN VALVE (NRV)

→ PRESSURE REDUCING VALVE (PRV)

ISOLATING VALVE

AIR VALVE (AV)

ZONAL METER

FIRE HYDRANT (FH)

BENCH MARK (BM)

HGL HYDRAULIC GRADE LINE

BUILDING

KISUMU WATER AND SANITATION COMPANY



KFW

KISUMU WATER SUPPLY
IMPROVEMENT AID ON DELIVERY-AOD PROJECT


DETAILED DESIGN

PLAN AND PROFILE LINE A1

A3 SIZE: AS SHOWN 1 OF 2





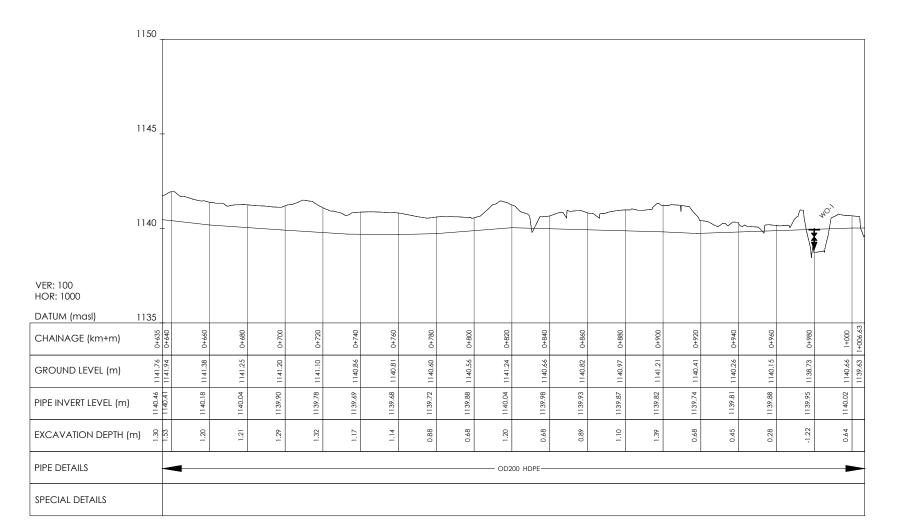

A1 - (1)-LONGITUDINAL PROFILE

- VERTICAL EXAGGERATION IN PROFILE IS 10 TIMES THE HORIZONTAL SCALE.
- . THIS DRAWING TO BE READ WITH ALL RELEVANT LAYOUTS PLAN AND STANDARD DRAWINGS
- 3. PIPE ROUTE TO BE ALIGNED TO MATCH THE FINAL WAYLEAVE

## LEGEND:

- PROPOSED WATER PIPE

KENHA BOUNDARY

NON RETURN VALVE (NRV)

→ PRESSURE REDUCING VALVE (PRV)

ISOLATING VALVE

AIR VALVE (AV)

WASHOUT (WO)

ZONAL METER

FIRE HYDRANT (FH)

BENCH MARK (BM) HGL HYDRAULIC GRADE LINE





KISUMU WATER AND SANITATION COMPANY



KFW

KISUMU WATER SUPPLY IMPROVEMENT AID ON DELIVERY-AOD PROJECT

DETAILED DESIGN

PLAN AND PROFILE LINE A1

A3 SIZE: AS SHOWN 2 OF 2





- VERTICAL EXAGGERATION IN PROFILE IS
   10 TIMES THE HORIZONTAL SCALE.
- THIS DRAWING TO BE READ WITH ALL RELEVANT LAYOUTS PLAN AND STANDARD DRAWINGS
- 3. PIPE ROUTE TO BE ALIGNED TO MATCH THE FINAL WAYLEAVE

## LEGEND:

PROPOSED WATER PIPE

KENHA BOUNDARY

NON RETURN VALVE (NRV)

→ PRESSURE REDUCING VALVE (PRV)

SOLATING VALVE

AIR VALVE (AV)

washout (wo)


ZONAL METER

FIRE HYDRANT (FH)

BENCH MARK (BM)

L HYDRAULIC GRADE LINE

BUILDING

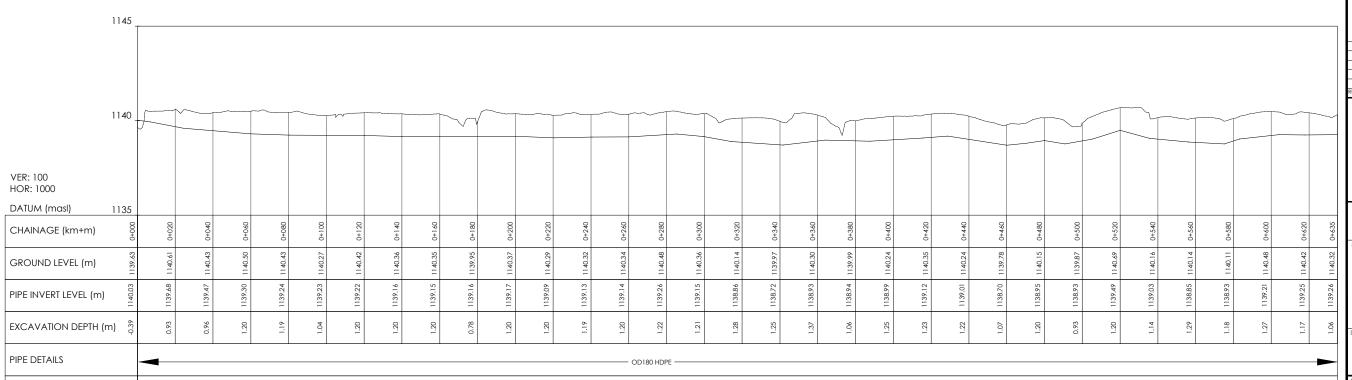

A2-LONGITUDINAL PROFILE

SPECIAL DETAILS

ISSUED OF CONSTRUCTION
REV DESCRIPTION DATE



KISUMU WATER AND SANITATION COMPANY



KFW MAN DEVELOPMENT BAN

KISUMU WATER SUPPLY IMPROVEMENT AID ON DELIVERY-AOD PROJECT

DETAILED DESIGN

DRAWING TITLE

PLAN AND PROFILE LINE A2

ONSULTANT:

yn Master P(a) R

Fifth Ngong, Avenue Office Su Room 12, P.O Box 58438-00200 Nairobi, Kenya

Gauff Consultan Africa

Chalbi Drive 3734, Lavington, P.O. Box 49817-00100 Nairobi, Kenya



LAYOUT PLAN SCALE 1:1000

# 1145 1140 VER: 100 HOR: 1000 DATUM (masl) 1135 CHAINAGE (km+m) GROUND LEVEL (m) 1141.20 PIPE INVERT LEVEL (m) EXCAVATION DEPTH (m) PIPE DETAILS - OD180 HDPE

# A2-LONGITUDINAL PROFILE

SPECIAL DETAILS

# NOTES:

- VERTICAL EXAGGERATION IN PROFILE IS 10 TIMES THE HORIZONTAL SCALE.
- THIS DRAWING TO BE READ WITH ALL RELEVANT LAYOUTS PLAN AND STANDARD DRAWINGS
- PIPE ROUTE TO BE ALIGNED TO MATCH THE FINAL WAYLEAVE

#### LEGEND:

PROPOSED WATER PIPE

KENHA BOUNDARY

NON RETURN VALVE (NRV)

→ PRESSURE REDUCING VALVE (PRV)

ISOLATING VALVE

AIR VALVE (AV)

WASHOUT (WO) ZONAL METER

FIRE HYDRANT (FH)

BENCH MARK (BM)

HYDRAULIC GRADE LINE

BUILDING





KISUMU WATER AND SANITATION COMPANY



KFW

KISUMU WATER SUPPLY IMPROVEMENT AID ON DELIVERY-AOD PROJECT


DETAILED DESIGN

PLAN AND PROFILE LINE A2

A3 SIZE: AS SHOWN 2 OF 5 KSM/DS/A2/02



# LAYOUT PLAN SCALE 1:1000

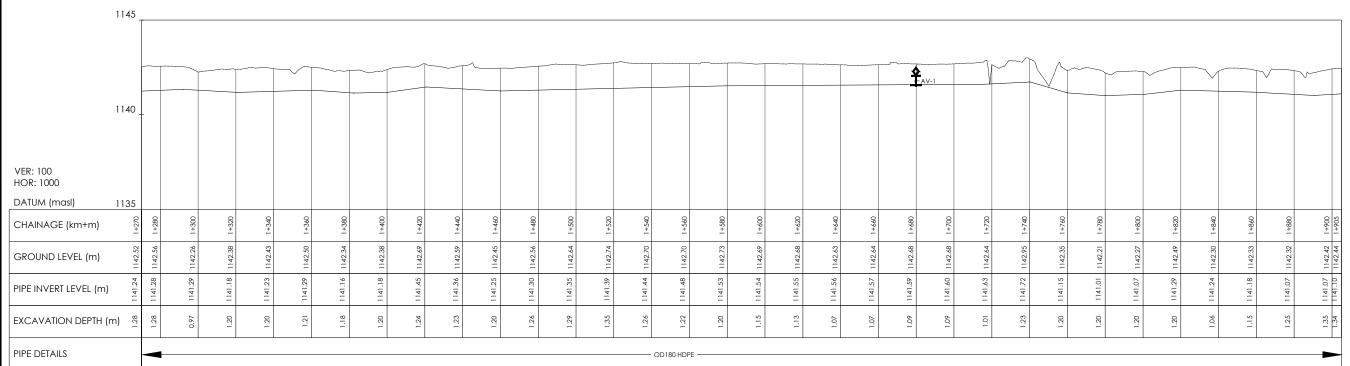

# **A2-LONGITUDINAL PROFILE**

SPECIAL DETAILS

## NOTES:

- VERTICAL EXAGGERATION IN PROFILE IS 10 TIMES THE HORIZONTAL SCALE.
- THIS DRAWING TO BE READ WITH ALL RELEVANT LAYOUTS PLAN AND STANDARD DRAWINGS
- B. PIPE ROUTE TO BE ALIGNED TO MATCH THE FINAL WAYLEAVE

## LEGEND:

PROPOSED WATER PIPE

KENHA BOUNDARY

NON RETURN VALVE (NRV)

→ PRESSURE REDUCING VALVE (PRV)

ISOLATING VALVE

AIR VALVE (AV)

WASHOUT (WO)

ZONAL METER

FIRE HYDRANT (FH)

BENCH MARK (BM)

HYDRAULIC GRADE LINE

BUILDING



KISUMU WATER AND SANITATION COMPANY



KFW

KISUMU WATER SUPPLY IMPROVEMENT AID ON DELIVERY-AOD PROJECT

DETAILED DESIGN

PLAN AND PROFILE LINE A2

A3 SIZE: AS SHOWN 3 OF 5 KSM/DS/A2/03



LAYOUT PLAN SCALE 1:1000

# 

# A2-LONGITUDINAL PROFILE

SPECIAL DETAILS

## NOTES:

- VERTICAL EXAGGERATION IN PROFILE IS
   10 TIMES THE HORIZONTAL SCALE.
- THIS DRAWING TO BE READ WITH ALL RELEVANT LAYOUTS PLAN AND STANDARD DRAWINGS
- 3. PIPE ROUTE TO BE ALIGNED TO MATCH THE FINAL WAYLEAVE

## LEGEND:

PROPOSED WATER PIPE

KENHA BOUNDARY

NON RETURN VALVE (NRV)

PRESSURE REDUCING VALVE (PRV)

ISOLATING VALVE

AIR VALVE (AV)

<del>-</del>

WASHOUT (WO)

 
ZONAL METER

FIRE HYDRANT (FH)

BENCH MARK (BM)

L HYDRAULIC GRADE LINE







KISUMU WATER AND SANITATION COMPANY



KFW RMAN DEVELOPMENT BAN

KISUMU WATER SUPPLY IMPROVEMENT AID ON DELIVERY-AOD PROJECT

DETAILED DESIGN

DRAWING TITL

PLAN AND PROFILE LINE A2

ONSULTANT:

Fifth Ngong, Avenue Office Room 12, P.O Box 58438-00 Nairobi, Kenya

Gauff Consultan

Chalbi Drive 3734, Lavington, P.O. Box 49817-00100 Nairobi,

 DESIGNED BY:
 JK
 DRAWN BY:
 MMG


 CHECKED BY:
 MG
 DATE:
 DEC 2024

 SCALE:
 A3 SIZE:
 A5 SHOWN
 SHEET NO:
 4 OF 5

 DRG NO:
 KSM/DS/A2/04
 REV.



LAYOUT PLAN SCALE 1:1000

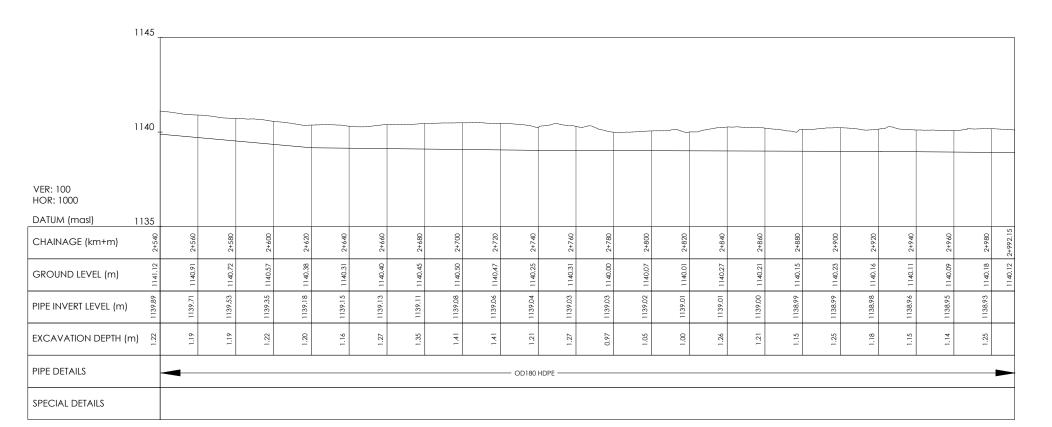

A2-LONGITUDINAL PROFILE

- VERTICAL EXAGGERATION IN PROFILE IS
   10 TIMES THE HORIZONTAL SCALE.
- THIS DRAWING TO BE READ WITH ALL RELEVANT LAYOUTS PLAN AND STANDARD DRAWINGS
- 3. PIPE ROUTE TO BE ALIGNED TO MATCH THE FINAL WAYLEAVE

## LEGEND:

PROPOSED WATER PIPE

KENHA BOUNDARY

NON RETURN VALVE (NRV)

PRESSURE REDUCING VALVE (PRV)

ISOLATING VALVE

AIR VALVE (AV)

washout (wo)

ZONAL METER

FIRE HYDRANT (FH)

BENCH MARK (BM)

HGL HYDRAULIC GRADE LINE



ISSUED OF CONSTRUCTION
REV DESCRIPTION



KISUMU WATER AND SANITATION COMPANY



KFW
MAN DEVELOPMENT BAN

OJECT:

KISUMU WATER SUPPLY IMPROVEMENT AID ON DELIVERY-AOD PROJECT

DETAILED DESIGN

DRAWING TITL

PLAN AND PROFILE LINE A2

CONSULTANT

**Dêsiyn** Mas

Fifth Ngong, Avenue Office Room 12, P.O Box 58438-002 Nairobi, Kenya

Gauff Consulto Africa Chalbi Drive 3734, Lavington, P.O. Box 49817-00100 Nairobi, Kenya



LAYOUT PLAN SCALE 1:1000

# 1145 1140 VER: 100 HOR: 1000 DATUM (masl) 1135 CHAINAGE (km+m) GROUND LEVEL (m) PIPE INVERT LEVEL (m) EXCAVATION DEPTH (m) PIPE DETAILS OD160 HDPE

A3-LONGITUDINAL PROFILE

SPECIAL DETAILS

# NOTES:

- VERTICAL EXAGGERATION IN PROFILE IS 10 TIMES THE HORIZONTAL SCALE.
- THIS DRAWING TO BE READ WITH ALL RELEVANT LAYOUTS PLAN AND STANDARD DRAWINGS
- 3. PIPE ROUTE TO BE ALIGNED TO MATCH THE FINAL WAYLEAVE

## LEGEND:

PROPOSED WATER PIPE

KENHA BOUNDARY

NON RETURN VALVE (NRV)

→ PRESSURE REDUCING VALVE (PRV)

ISOLATING VALVE

AIR VALVE (AV)

WASHOUT (WO)

 
ZONAL METER

FIRE HYDRANT (FH)

BENCH MARK (BM)

HYDRAULIC GRADE LINE

BUILDING





KISUMU WATER AND SANITATION COMPANY



KFW

KISUMU WATER SUPPLY IMPROVEMENT AID ON DELIVERY-AOD PROJECT

DETAILED DESIGN


PLAN AND PROFILE LINE A3

A3 SIZE: AS SHOWN 1 OF 2 KSM/DS/A3/01





LAYOUT PLAN SCALE 1:1000

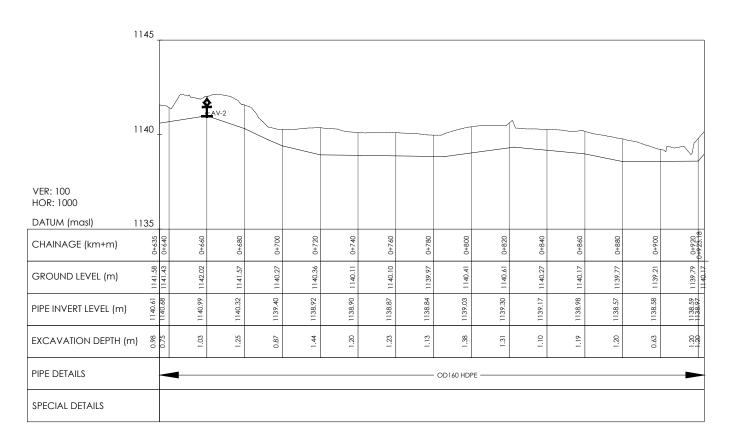

# A3-LONGITUDINAL PROFILE

APPURTENANCE TABLE				
Y COORDINATES	X-COORDINATES	CHAINAGE	PIPE DIAMETER	
9987321.7	698896.4	1+680.00	DN180	
9985554.3	699713.1	0+660.00	DN160	
9988046.9	697467.3	0+980.00	DN200	
9987878.5	698262.3	0+800.00	DN180	
9985765.9	699653.3	0+440.00	DN160	
	Y COORDINATES 9987321.7 9985554.3 9988046.9 9987878.5	Y COORDINATES X-COORDINATES  9987321.7 698896.4  9985554.3 699713.1  9988046.9 697467.3  9987878.5 698262.3	Y COORDINATES X-COORDINATES CHAINAGE 9987321.7 698896.4 1+680.00 9985554.3 699713.1 0+660.00 9988046.9 697467.3 0+980.00 9987878.5 698262.3 0+800.00	

# NOTES:

- VERTICAL EXAGGERATION IN PROFILE IS 10 TIMES THE HORIZONTAL SCALE.
- THIS DRAWING TO BE READ WITH ALL RELEVANT LAYOUTS PLAN AND STANDARD DRAWINGS
- 3. PIPE ROUTE TO BE ALIGNED TO MATCH THE FINAL WAYLEAVE

## LEGEND:

PROPOSED WATER PIPE

KENHA BOUNDARY

NON RETURN VALVE (NRV)

→ PRESSURE REDUCING VALVE (PRV)

ISOLATING VALVE

AIR VALVE (AV)

WASHOUT (WO)

ZONAL METER

FIRE HYDRANT (FH)

BENCH MARK (BM)

HGL HYDRAULIC GRADE LINE







KISUMU WATER AND SANITATION COMPANY





KISUMU WATER SUPPLY IMPROVEMENT AID ON DELIVERY-AOD PROJECT

DETAILED DESIGN


PLAN AND PROFILE LINE A3



A3 SIZE: AS SHOWN SHEET NO: 2 OF 2 KSM/DS/A3/02





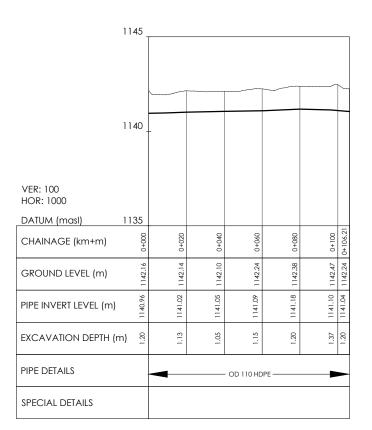

**B1-LONGITUDINAL PROFILE** 

- VERTICAL EXAGGERATION IN PROFILE IS
   TO TIMES THE HORIZONTAL SCALE.
- THIS DRAWING TO BE READ WITH ALL RELEVANT LAYOUTS PLAN AND STANDARD DRAWINGS
- 3. PIPE ROUTE TO BE ALIGNED TO MATCH THE FINAL WAYLEAVE

## LEGEND:

PROPOSED WATER PIPE

NON RETURN VALVE (NRV)

PRESSURE REDUCING VALVE (PRV)

ISOLATING VALVE

AIR VALVE (AV)

WASHOUT (WO)

ZONAL METER

FIRE HYDRANT (

FIRE HYDRANT (FH)

BENCH MARK (BM)

HGL HYDRAULIC GRADE LINE

	ISSUED OF CONSTRUCTION	
REV	DESCRIPTION	DATE



KISUMU WATER AND SANITATION COMPANY



KFW RMAN DEVELOPMENT BAN

ROJECT:

KISUMU WATER SUPPLY
IMPROVEMENT AID ON DELIVERYAOD PROJECT

DETAILED DESIGN

DRAWING TITLE:

PLAN AND PROFILE LINE B1

CONSULTANT:

**Design Master P** 

/ENTURE WITH Chalbi Drive 3734, Lavingt


DESIGNED BY: JK DRAWN BY: MMG
CHECKED BY: MG DATE: DEC 2024

SCALE: A3 SUE: AS SHOWN SHEET NO: 1 OF 1

DRG NO: KSM/DS/B1/01 REV.





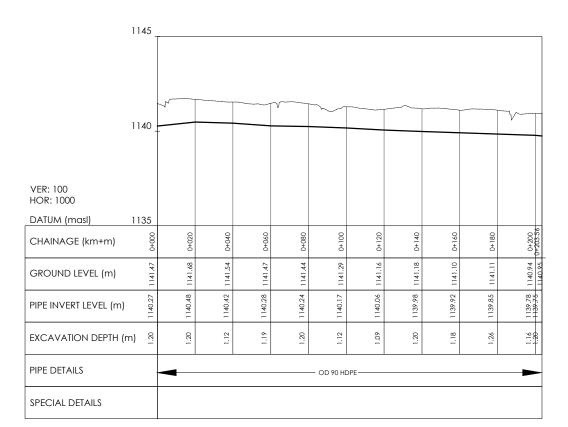

C1-LONGITUDINAL PROFILE

- VERTICAL EXAGGERATION IN PROFILE IS 10 TIMES THE HORIZONTAL SCALE.
- THIS DRAWING TO BE READ WITH ALL RELEVANT LAYOUTS PLAN AND STANDARD DRAWINGS
- 3. PIPE ROUTE TO BE ALIGNED TO MATCH THE FINAL WAYLEAVE

## LEGEND:

<del>4</del> <del>7</del> ¬

PROPOSED WATER PIPE

NON RETURN VALVE (NRV)

PRESSURE REDUCING VALVE (PRV)

ISOLATING VALVE

AIR VALVE (AV)

WASHOUT (WO)

ZONAL METER

FIRE HYDRANT (FH)

BENCH MARK (BM)

HGL HYDRAULIC GRADE LINE





KISUMU WATER AND SANITATION COMPANY





KISUMU WATER SUPPLY IMPROVEMENT AID ON DELIVERY-AOD PROJECT

DETAILED DESIGN


PLAN AND PROFILE LINE C1





JK	DRAWN BY: MMG
CHECKED BY: MG	DATE: DEC 2024
SCALE: A3 SIZE: AS SHOWN	SHEET No: 1 OF 1
DRG No: KSM/DS/C1/01	REV.



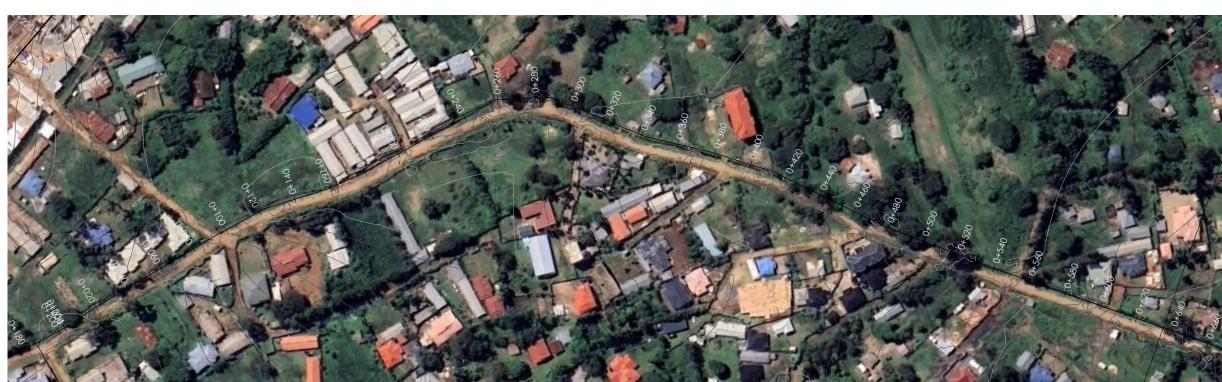

- VERTICAL EXAGGERATION IN PROFILE IS 10 TIMES THE HORIZONTAL SCALE.
- THIS DRAWING TO BE READ WITH ALL RELEVANT LAYOUTS PLAN AND STANDARD DRAWINGS
- 3. PIPE ROUTE TO BE ALIGNED TO MATCH THE FINAL WAYLEAVE

## LEGEND:

PROPOSED WATER PIPE

NON RETURN VALVE (NRV)

PRESSURE REDUCING VALVE (PRV)

ISOLATING VALVE


AIR VALVE (AV)

WASHOUT (WO)

FIRE HYDRANT (FH)

BENCH MARK (BM)

HYDRAULIC GRADE LINE

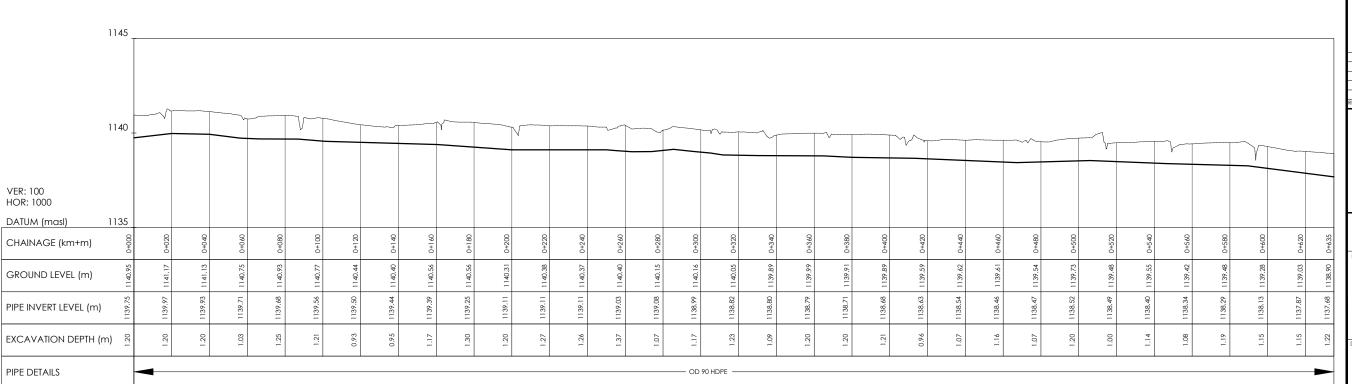

C2-LONGITUDINAL PROFILE

SPECIAL DETAILS



KISUMU WATER AND SANITATION COMPANY



**KFW** 

KISUMU WATER SUPPLY IMPROVEMENT AID ON DELIVERY-AOD PROJECT


DETAILED DESIGN

PLAN AND PROFILE LINE C2

SHEET No: 1 OF 2 ORG No: KSM/DS/C2/01





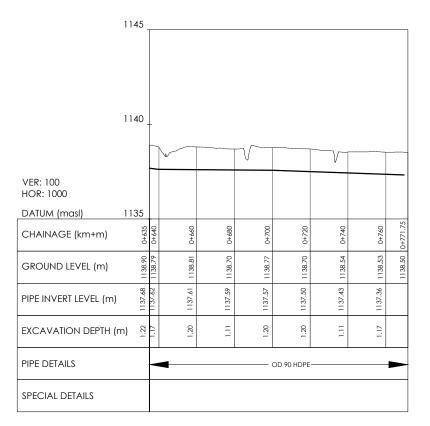

C2-LONGITUDINAL PROFILE

- VERTICAL EXAGGERATION IN PROFILE IS
   10 TIMES THE HORIZONTAL SCALE.
- THIS DRAWING TO BE READ WITH ALL RELEVANT LAYOUTS PLAN AND STANDARD DRAWINGS
- PIPE ROUTE TO BE ALIGNED TO MATCH THE FINAL WAYLEAVE

# LEGEND:

PROPOSED WATER PIPE

NON RETURN VALVE (NRV)

PRESSURE REDUCING VALVE (PRV)

SOLATING VALVE

AIR VALVE (AV)

WASHOUT (WO)

ZONAL METER

201012111

FIRE HYDRANT (FH)

BENCH MARK (BM)

HGL HYDRAULIC GRADE LINE





KISUMU WATER AND SANITATION COMPANY





ROJECT:

KISUMU WATER SUPPLY
IMPROVEMENT AID ON DELIVERYAOD PROJECT

DETAILED DESIGN

DRAWING TITLE

PLAN AND PROFILE LINE C2

CONSULTANT:




Fifth Ngong, Avenue Office Su Room 12, P.O Box 58438-00200 Nairobi, Kenya

Gauff Chalbi Drive 373
Consultants Africa P.O. Box 49817-0
Kenya

DESIGNED BY: JK	DRAWN BY: MMG	
CHECKED BY: MG	DATE: DEC 2024	
SCALE: A3 SIZE: AS SHOWN	SHEET No: 2 OF 2	
DRG No:	REV.	





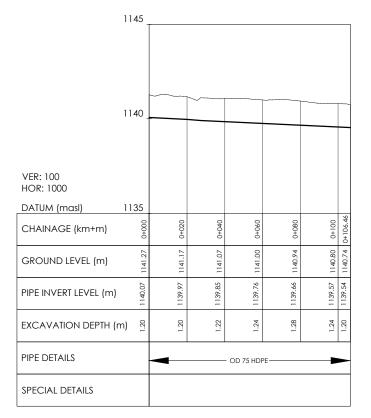

D1-LONGITUDINAL PROFILE

- VERTICAL EXAGGERATION IN PROFILE IS
   10 TIMES THE HORIZONTAL SCALE.
- THIS DRAWING TO BE READ WITH ALL
  RELEVANT LAYOUTS PLAN AND STANDARD
  DRAWINGS
- PIPE ROUTE TO BE ALIGNED TO MATCH THE FINAL WAYLEAVE

# LEGEND:

PROPOSED WATER PIPE

NON RETURN VALVE (NRV)

PRESSURE REDUCING VALVE (PRV)

ISOLATING VALVE

AIR VALVE (AV)

WASHOUT (WO)

ZONAL METER

H EIBE HVDBANIT (EI

FIRE HYDRANT (FH)

BENCH MARK (BM)

HGL HYDRAULIC GRADE LINE

	ISSUED OF CONSTRUCTION	
REV	DESCRIPTION	DATE



KISUMU WATER AND SANITATION COMPANY





PROJECT:

KISUMU WATER SUPPLY
IMPROVEMENT AID ON DELIVERYAOD PROJECT

DETAILED DESIGN

DRAWING TITLE

PLAN AND PROFILE LINE D1

CONSULTANT:



Fifth Ngong, Avenue Office Room 12, P.O Box 58438-00 Ngirobi, Kenya

IN JOINT VENTURE

Gauff


Chalbi Drive 3734, Lavington P.O. Box 49817-00100 Nairobi Kenya

DESIGNED BY: JK	DRAWN BY: MMG	
CHECKED BY: MG	DATE: DEC 2024	
SCALE: A3 SIZE: AS SHOWN	SHEET NO: 1 OF 1	
DRG No: KSM/DS/D1/01	REV.	







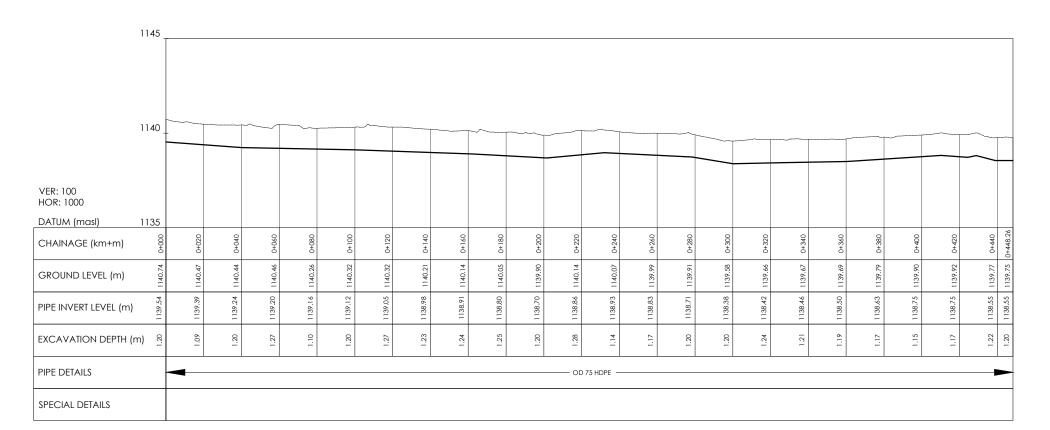

# D2-LONGITUDINAL PROFILE

## NOTES:

- VERTICAL EXAGGERATION IN PROFILE IS 10 TIMES THE HORIZONTAL SCALE.
- THIS DRAWING TO BE READ WITH ALL RELEVANT LAYOUTS PLAN AND STANDARD DRAWINGS
- 3. PIPE ROUTE TO BE ALIGNED TO MATCH THE FINAL WAYLEAVE

# LEGEND:

PROPOSED WATER PIPE

NON RETURN VALVE (NRV)

PRESSURE REDUCING VALVE (PRV)

ISOLATING VALVE

AIR VALVE (AV)

WASHOUT (WO)

ZONAL METER

FIRE HYDRANT (FH)

BENCH MARK (BM)

HGL HYDRAULIC GRADE LINE

	ISSUED OF CONSTRUCTION	
REV	DESCRIPTION	DATE



KISUMU WATER AND SANITATION COMPANY



KFW

KISUMU WATER SUPPLY IMPROVEMENT AID ON DELIVERY-AOD PROJECT


DETAILED DESIGN

PLAN AND PROFILE LINE D2

DESIGNED BY: JK	DRAWN BY: MMG
CHECKED BY: MG	DATE: DEC 2024
SCALE: A3 SIZE: AS SHOWN	SHEET No: 1 OF 1
DRG No:	REV.





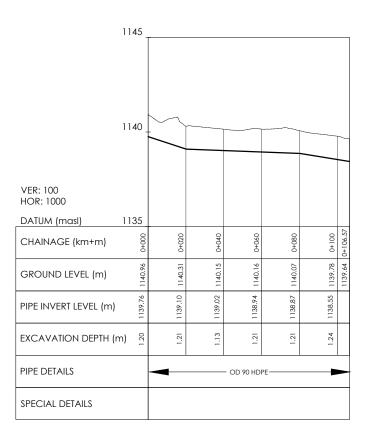

E1-LONGITUDINAL PROFILE

- VERTICAL EXAGGERATION IN PROFILE IS 10 TIMES THE HORIZONTAL SCALE.
- THIS DRAWING TO BE READ WITH ALL RELEVANT LAYOUTS PLAN AND STANDARD DRAWINGS
- 3. PIPE ROUTE TO BE ALIGNED TO MATCH THE FINAL WAYLEAVE

## LEGEND:

PROPOSED WATER PIPE

NON RETURN VALVE (NRV)

PRESSURE REDUCING VALVE (PRV)

ISOLATING VALVE

AIR VALVE (AV)

WASHOUT (WO)

FIRE HYDRANT (FH)

BENCH MARK (BM)

HGL HYDRAULIC GRADE LINE



KISUMU WATER AND SANITATION COMPANY





KISUMU WATER SUPPLY IMPROVEMENT AID ON DELIVERY-AOD PROJECT


DETAILED DESIGN

PLAN AND PROFILE LINE E1

SCALE: A3 SIZE: SHEET NO: 1 OF 1





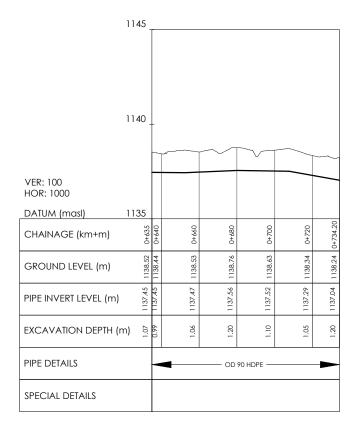

E2-LONGITUDINAL PROFILE

- VERTICAL EXAGGERATION IN PROFILE IS 10 TIMES THE HORIZONTAL SCALE.
- THIS DRAWING TO BE READ WITH ALL RELEVANT LAYOUTS PLAN AND STANDARD DRAWINGS
- 3. PIPE ROUTE TO BE ALIGNED TO MATCH THE FINAL WAYLEAVE

## LEGEND:

PROPOSED WATER PIPE

NON RETURN VALVE (NRV)

PRESSURE REDUCING VALVE (PRV)

ISOLATING VALVE

AIR VALVE (AV)

WASHOUT (WO)

ZONAL METER

FIRE HYDRANT (FH)

BENCH MARK (BM)

HGL HYDRAULIC GRADE LINE



KISUMU WATER AND SANITATION COMPANY





KISUMU WATER SUPPLY IMPROVEMENT AID ON DELIVERY-AOD PROJECT

DETAILED DESIGN

PLAN AND PROFILE LINE E2

SCALE: A3 SIZE: SHEET NO: 2 OF 2



LAYOUT PLAN SCALE 1:1000

# 1145 1140 VER: 100 HOR: 1000 DATUM (masl) CHAINAGE (km+m) GROUND LEVEL (m) PIPE INVERT LEVEL (m) EXCAVATION DEPTH (m) 월 PIPE DETAILS OD 90 HDPE-

# E2-LONGITUDINAL PROFILE

SPECIAL DETAILS

# NOTES :

- VERTICAL EXAGGERATION IN PROFILE IS 10 TIMES THE HORIZONTAL SCALE.
- THIS DRAWING TO BE READ WITH ALL RELEVANT LAYOUTS PLAN AND STANDARD DRAWINGS
- E. PIPE ROUTE TO BE ALIGNED TO MATCH THE FINAL WAYLEAVE

## LEGEND:

PROPOSED WATER PIPE

NON RETURN VALVE (NRV)

PRESSURE REDUCING VALVE (PRV)

ISOLATING VALVE

AIR VALVE (AV)

WASHOUT (WO)

FIRE HYDRANT (FH)

BENCH MARK (BM)

HYDRAULIC GRADE LINE





KISUMU WATER AND SANITATION COMPANY



**KFW** 

KISUMU WATER SUPPLY IMPROVEMENT AID ON DELIVERY-AOD PROJECT


DETAILED DESIGN

PLAN AND PROFILE LINE E2

SHEET No: 1 OF 2





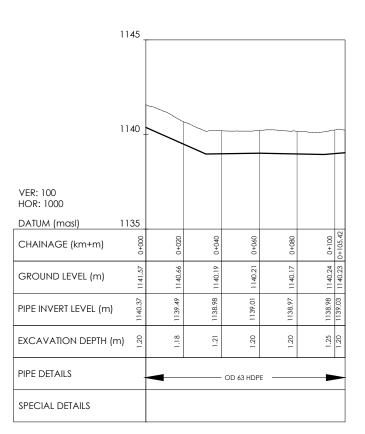

F1-LONGITUDINAL PROFILE



- VERTICAL EXAGGERATION IN PROFILE IS
   10 TIMES THE HORIZONTAL SCALE.
- THIS DRAWING TO BE READ WITH ALL RELEVANT LAYOUTS PLAN AND STANDARD DRAWINGS
- 3. PIPE ROUTE TO BE ALIGNED TO MATCH THE FINAL WAYLEAVE

# LEGEND:

PROPOSED WATER PIPE

NON RETURN VALVE (NRV)

PRESSURE REDUCING VALVE (PRV)

ISOLATING VALVE

AIR VALVE (AV)

 
WASHOUT (WO)

ZONAL METER

FIRE HYDRANT (FH)

BENCH MARK (BM)

HGL HYDRAULIC GRADE LINE





KISUMU WATER AND SANITATION COMPANY





PROJECT:

KISUMU WATER SUPPLY IMPROVEMENT AID ON DELIVERY-AOD PROJECT

DETAILED DESIGN

DRAWING TITLE

PLAN AND PROFILE LINE F1

CONSULTANT:



Fifth Ngong, Avenue Office Room 12, P.O Box 58438-002 Nairobi, Kenya


Gauff Ch Consultants P.C Africa Ker

Chalbi Drive 3734, Lavington P.O. Box 49817-00100 Nairobi Kenya







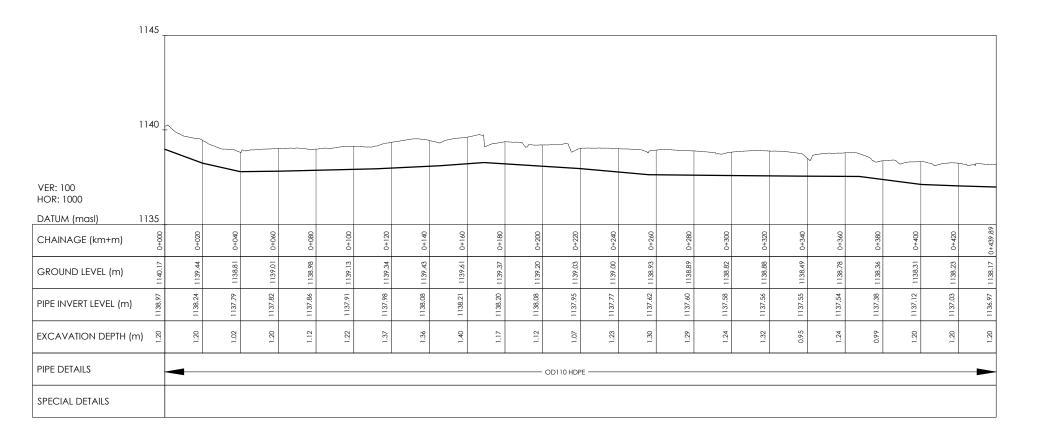

# G1-LONGITUDINAL PROFILE

## NOTES:

- VERTICAL EXAGGERATION IN PROFILE IS 10 TIMES THE HORIZONTAL SCALE.
- THIS DRAWING TO BE READ WITH ALL RELEVANT LAYOUTS PLAN AND STANDARD DRAWINGS
- 3. PIPE ROUTE TO BE ALIGNED TO MATCH THE FINAL WAYLEAVE

# LEGEND:

PROPOSED WATER PIPE

NON RETURN VALVE (NRV)

PRESSURE REDUCING VALVE (PRV)

ISOLATING VALVE

AIR VALVE (AV)

WASHOUT (WO)

FIRE HYDRANT (FH)

BENCH MARK (BM)

HGL HYDRAULIC GRADE LINE

	ISSUED OF CONSTRUCTION	
REV	DESCRIPTION	DATE



KISUMU WATER AND SANITATION COMPANY



KFW


KISUMU WATER SUPPLY IMPROVEMENT AID ON DELIVERY-AOD PROJECT


DETAILED DESIGN

PLAN AND PROFILE LINE G1


DESIGNED BY: JK	DRAWN BY: MMG	
CHECKED BY: MG	DATE: DEC 2024	
SCALE: A3 SIZE: AS SHOWN	SHEET NO: 1 OF 1	
DRG No:	REV.	


	T		
		General Location	
1	KSM-GL-01	Project Overview Map	1 Sheet
		Distribution System	
1	KSM-DS-GL	General Layout	1 Sheet
2	KSM-DS-A1	Line A1	2 Sheets
3	KSM-DS-A2	Line A2	5 Sheets
4	KSM-DS-A3	Line A3	2 Sheets
5	KSM-DS-B1	Line B1	1 Sheet
6	KSM-DS-C1	Line C1	1 Sheet
7	KSM-DS-C2	Line C2	2 Sheets
8	KSM-DS-D1	Line D1	1 Sheet
9	KSM-DS-D2	Line D2	1 Sheet
10	KSM-DS-E1	Line E1	1 Sheet
11	KSM-DS-E2	Line E2	2 Sheets
12	KSM-DS-F1	Line F1	1 Sheet
13	KSM-DS-G1	Line G1	1 Sheet
		Standard Drawings	
1	KSM-SD-01	Signboard Details	1 Sheet
2	KSM-SD-02	Marker Post Details	1 Sheet
3	KSM-SD-03	Air Valve Details	1 Sheet
4	KSM-SD-04	Washout Details TYPE A	1 Sheet
	KSM-SD-04	Washout Details TYPE B	1 Sheet
5	KSM-SD-05	Fire Hydrant Details	1 Sheet
6	KSM-SD-06	Valve Surface Box Details	1 Sheet
7	KSM-SD-07	Valve Chamber Details	1 Sheet
8	KSM-SD-08	Bulk Meter Chamber for Turbine Meter	1 Sheet
9	KSM-SD-09	Consumer Connection details	1 Sheet
10	KSM-SD-10	Pipe Bedding Details	1 Sheet
11	KSM-SD-11	Tank Level Indicator,Ladder,Handrail and Step Iron Details	1 Sheet
12	KSM-SD-12	Access Road Details Concrete Paving Stones&Murram	2 Sheets
13	KSM-SD-13	Steel Elevated Tank 500m3	1 Sheets

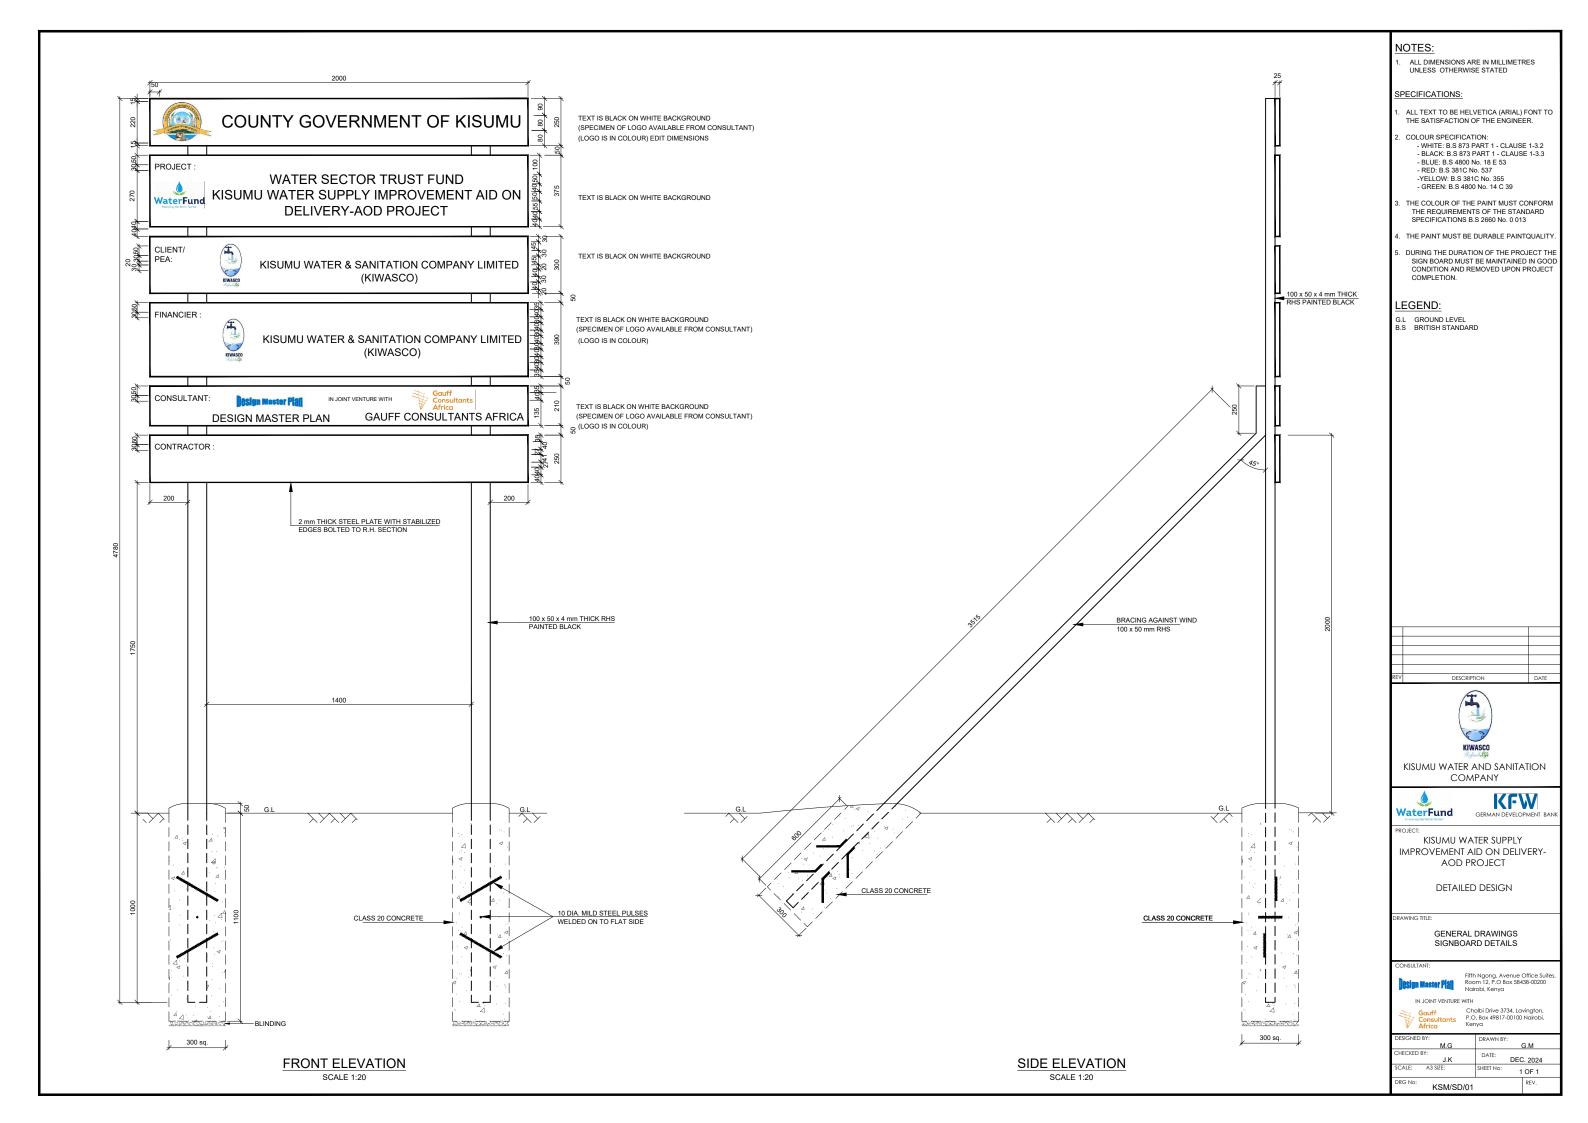

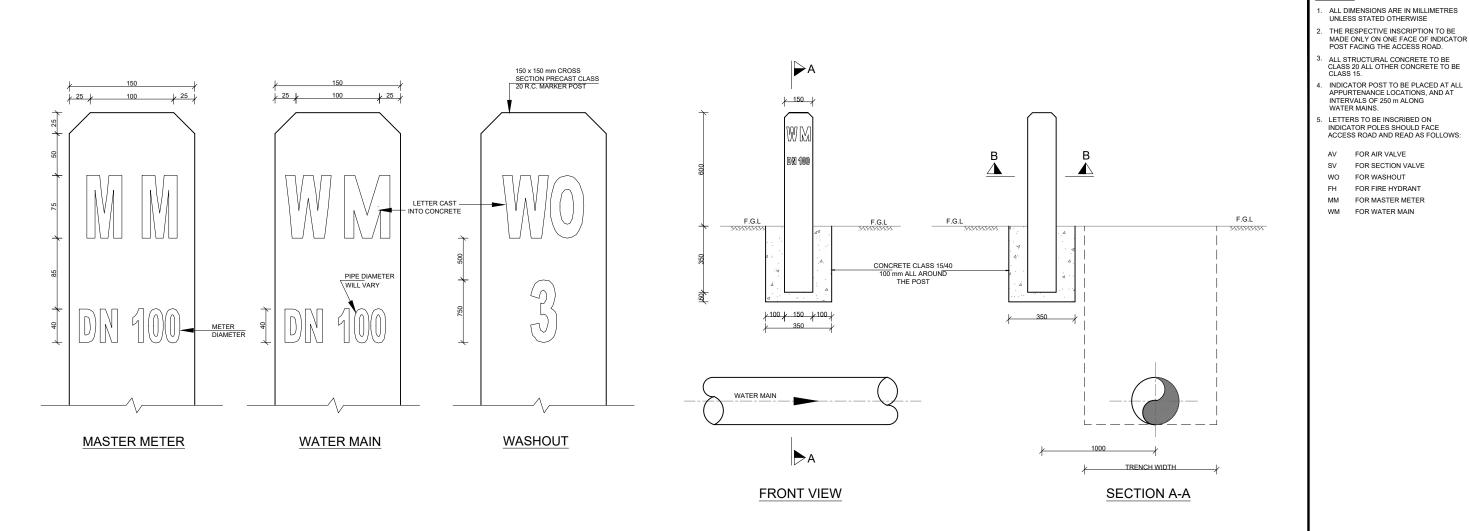

# PIPELINE MARKER POST POSITION

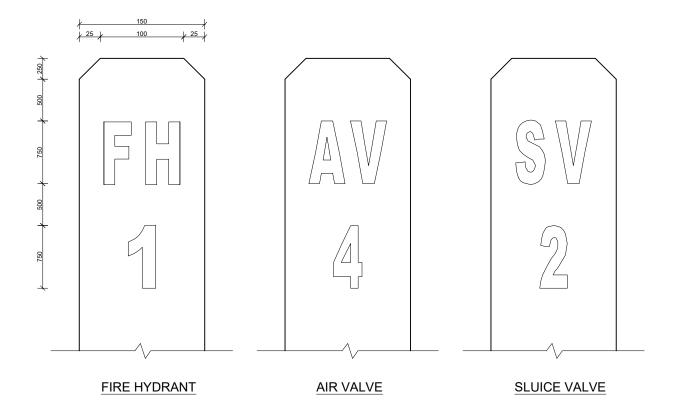

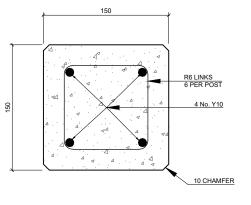

## SECTION B-B SCALE 1:5

# BAR BENDING SCHEDULE

ВА	R	No. OFF	TYPE	LENGTH
Y10	)	4	STRAIGHT	1000
R6		6		500
			100	

AOD PROJECT

PROJECT:

KISUMU WATER SUPPLY

IMPROVEMENT AID ON DELIVERY-

KIWASCO Refeesh Life KISUMU WATER AND SANITATION COMPANY

**KFW** 

DETAILED DESIGN

WaterFund

NOTES:

AV FOR AIR VALVE

FOR SECTION VALVE FOR WASHOUT FOR FIRE HYDRANT FOR MASTER METER

FOR WATER MAIN


GENERAL DRAWINGS MARKER POST DETAILS

Fifth Ngong, Avenue Office Suite Room 12, P.O Box 58438-00200 Nairobi, Kenya



DEC. 2024 1 OF 1 KSM/SD/02


## MARKER POST DETAILS SCALE 1:5

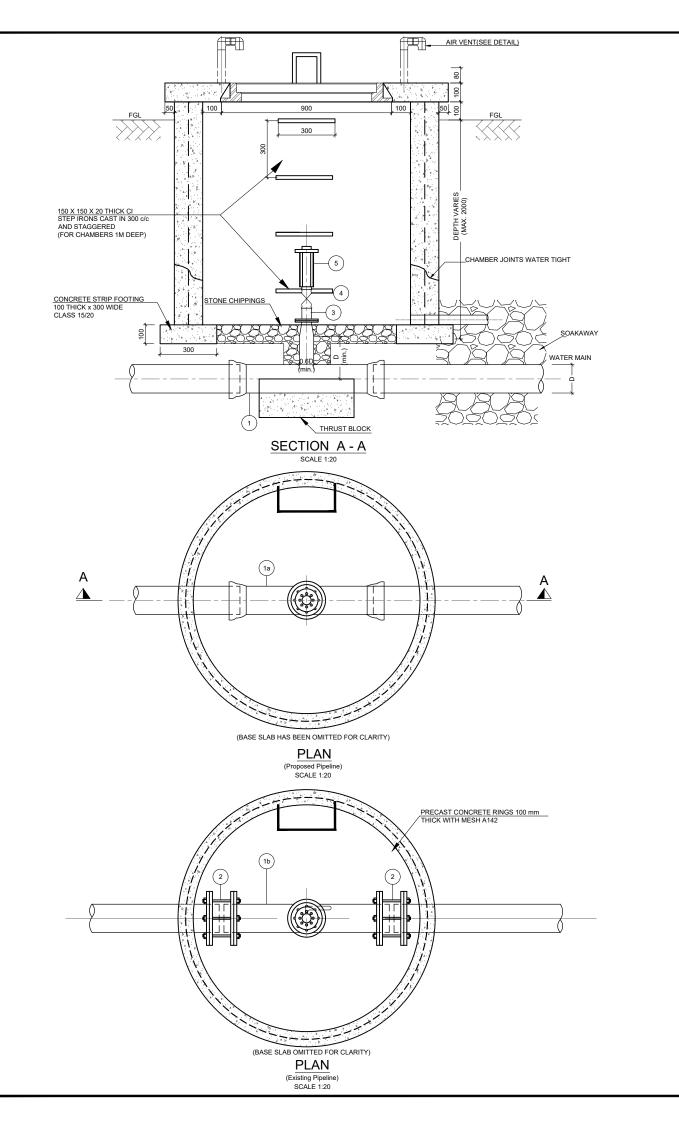

# SCHEDULE OF PIPEWORK & FITTINGS (DN 25 & 50)


ITEM	DESCRIPTION	DIAMETER	No.
1a	SOCKETED TEE WITH FLANGED BRANCH (NEW PIPELINES) *	D/0.6D (min.)	1
1b	PLAIN ENDED TEE WITH FLANGED BRANCH (EXISTING PIPELINE) **	D/0.6D (min.)	1
2	STEPPED COUPLING TO SUIT EXISTING PIPELINES **	D	2
3	THREADED AIR VALVE FLANGE ADAPTOR PIECE	0.6D/50(or 25)	1
4	FEMALE THREADED STOP COCK/ISOLATOR	50(or 25)	1
5	THREADED ANTI-SHOCK ANTI-SURGE AIR VALVE	50(or 25)	1

\* Proposed

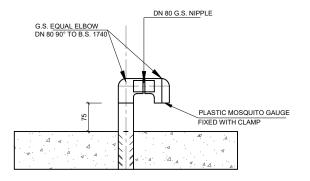

# **DETAILS OF AIR VENT IN CHAMBER**

SCALE 1:10

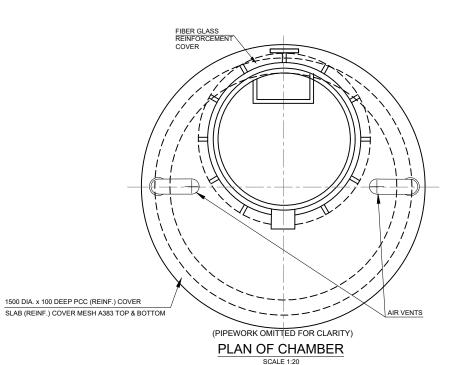


## NOTES:

- . ALL DIMENSIONS ARE IN MILLIMETRES UNLESS OTHERWISE STATED
- EXCEPT WHERE NOTED OTHERWISE, CONCRETE CLASS:
  BASES AND BEAMS = 25/20
  LEAN CONCRETE = 15/20
- ENSURE THAT THE SURFACE AREA OF THE VENT HOLES ARE LARGER THAN THAT OF THE AIR VALVE

# LEGEND:

 FGL FINISHED GROUND LEVEL





KISUMU WATER AND SANITATION COMPANY



KFW

KISUMU WATER SUPPLY
IMPROVEMENT AID ON DELIVERY-AOD PROJECT


DETAILED DESIGN

GENERAL DRAWINGS AIR VALVE DETAILS (DN 25 AND DN 50)




KSM/SD/03

DEC. 2024 1 OF 1

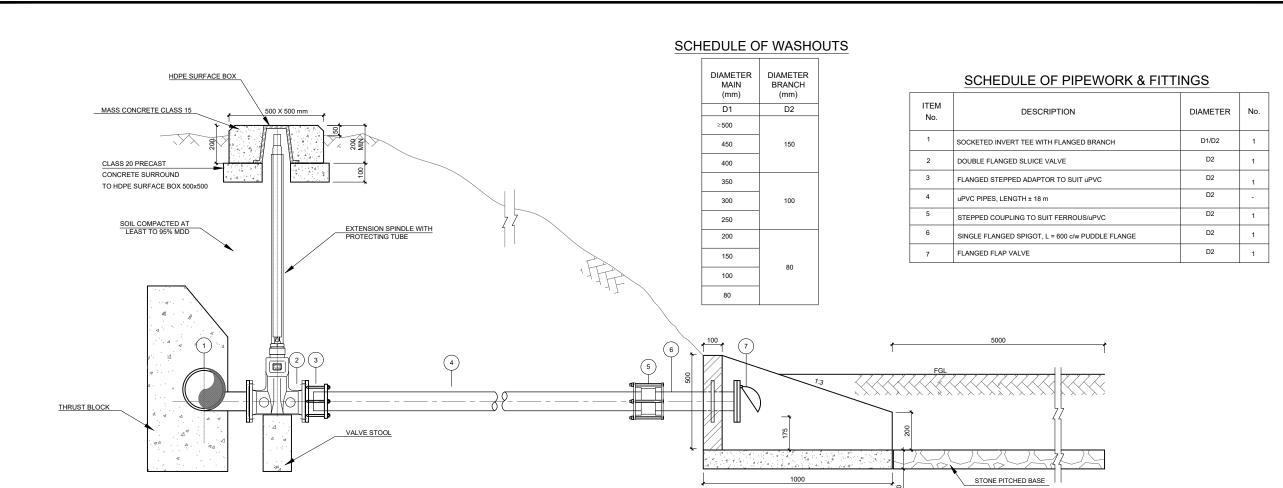

SECTION A-A

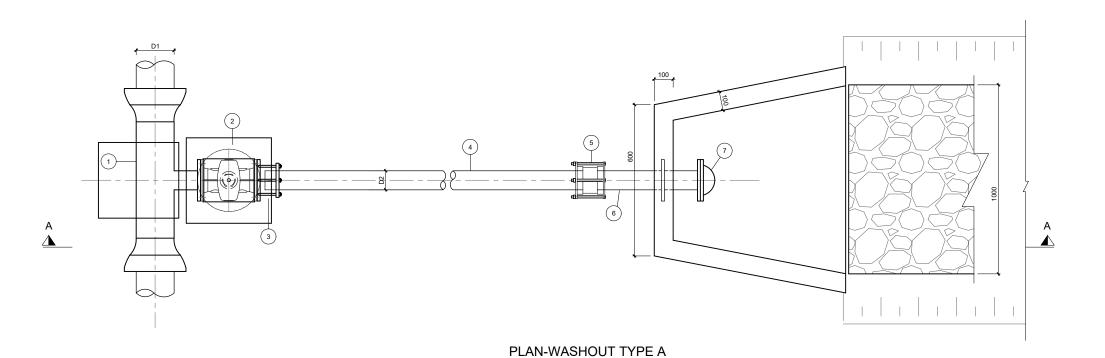


SCALE 1:20

## NOTES:

 - ALL DIMENSIONS ARE IN MILLIMETRES UNLESS STATED OTHERWISE
- EXCEPT WHERE NOTED OTHERWISE, CONCRETE CLASS:
   BASES AND BEAMS = 25/20 LEAN CONCRETE = 15/20

# LEGEND:

FGL FINISHED GROUND LEVEL





KISUMU WATER AND SANITATION COMPANY



KFW ERMAN DEVELOPMENT BA

KISUMU WATER SUPPLY
IMPROVEMENT AID ON DELIVERYAOD PROJECT

DETAILED DESIGN

DRAWING TITLE

GENERAL DRAWINGS WASHOUT DETAILS (TYPE A)


CONSULTAN



Fifth Ngong, Avenue Office Room 12, P.O Box 58438-00 Nairobi, Kenya



Chalbi Drive 3734, Lavington, P.O. Box 49817-00100 Nairobi, Kenya

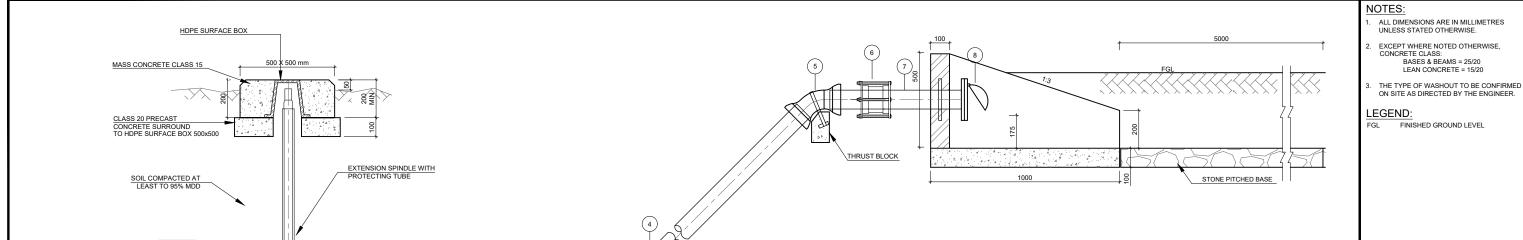

THRUST BLOCK

SECTION B - B

PLAN-WASHOUT TYPE B


THRUST BLOCK

SCHEDULE OF WASHOUTS

DIAMETER MAIN (mm)	DIAMETER BRANCH (mm)
D1	D2
≥500	
450	150
400	
350	
300	100
250	
200	
150	80
100	60
80	

# SCHEDULE OF PIPEWORK & FITTINGS

ITEM	DESCRIPTION	DIAMETER	No.
1	SOCKETED INVERT TEE WITH FLANGED BRANCH	D1/D2	1
2	DOUBLE FLANGED SLUICE VALVE	D2	1
3	FLANGED STEPPED ADAPTOR TO SUIT uPVC	D2	1
4	uPVC PIPES, LENGTH ± 18 m	D2	-
5	DOUBLE SOCKETED 45° BEND uPVC	D2	2
6	STEPPED COUPLING TO SUIT FERROUS/uPVC	D2	1
7	SINGLE FLANGED SPIGOT, L = 600 c/w PUDDLE FLANGE	D2	1
8	FLANGED FLAP VALVE	D2	1

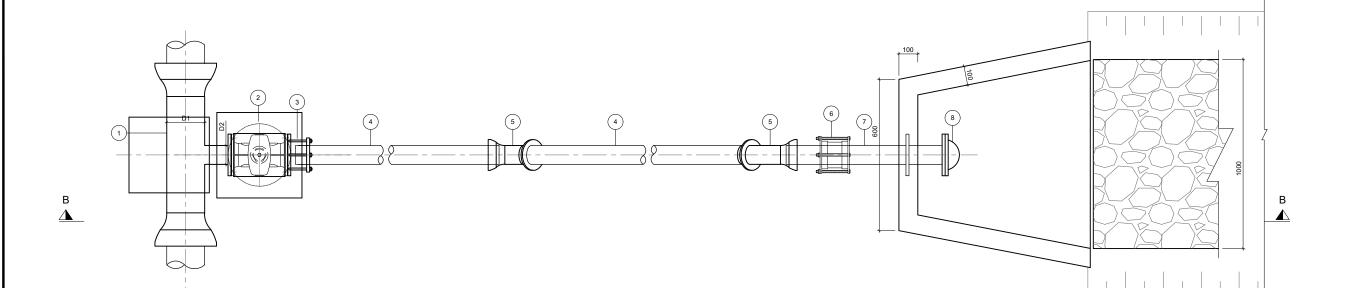



KISUMU WATER AND SANITATION COMPANY

WaterFund


**KFW** 

KISUMU WATER SUPPLY IMPROVEMENT AID ON DELIVERY-AOD PROJECT


DETAILED DESIGN

GENERAL DRAWINGS WASHOUT DETAILS (TYPE B)

DESIGNED	BY:	DRAWN BY:		
	M.G			G.M
CHECKED	BY:	DATE:		
	J.K	DAIL.	DEC	C. 2024
SCALE:	A3 SIZE:	SHEET No:	2	2 OF 2
DRG No:	KCM/CD/04	•		REV.

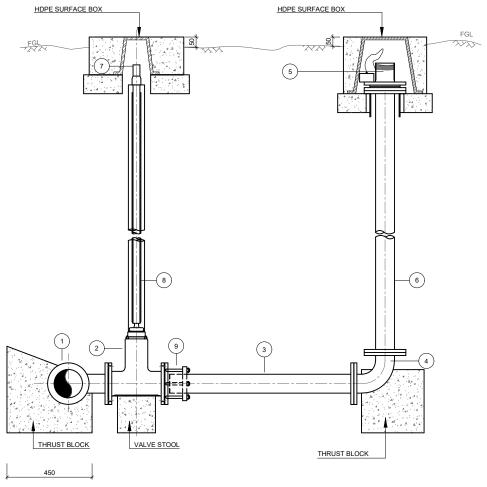

# SECTION A - A SCALE 1:20

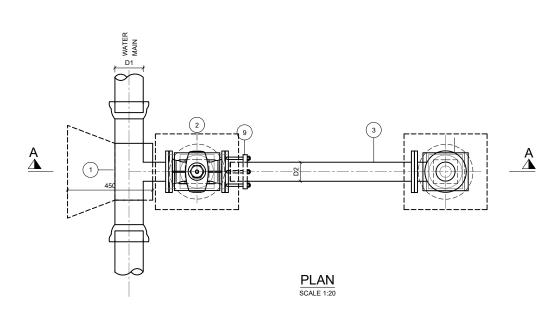

# SCHEDULE OF FIRE HYDRANT

ITEM

2

3

DIAMETER MAIN (mm)	DIAMETER HYDRANT (mm)
D1	D2
300	
250	80
200	00
150	
100	50
80	3

# NOTES:

SCHEDULE OF PIPEWORK & FITTINGS PER HYDRANT

DESCRIPTION

SOCKETED TEE WITH FLANGED BRANCH

FLANGED BEND, LONG RADIUS 90°

EXTENSION SPINDLE AND PROTECTING TUBE

FLANGED HYDRANT WITH CAP

SINGLE FLANGED PIPE PIECE , LENGTH = 1m TO 2m

DOUBLE FLANGED PIPE PIECE LENGTH NOT EXCEEDING 1m

FLANGED GATE VALVE

SPINDLE CAP

FLANGE ADAPTOR

DIAMETER

D1/D2

D2

D2

D2

D2

D2

QTY.

1

1

1

1

1

1

- TOP OF SLUICE VALVE SPINDLE CAP TO BE A MINIMUM DISTANCE OF 150 mm BELOW TOP OF SURFACE BOX.
- HYDRANTS TO BE LOCATED ON WATER MAINS ABOVE 150 mm DIA. AS DIRECTED BY THE ENGINEER.
- 3. HYDRANT TO SSRN No. 509 TYPE OR EQUIVALENT AND TO BE APPROVED BY LOCAL AUTHORITY.

#### NOTES

- ALL DIMENSIONS ARE IN MILLIMETRES
   UNLESS STATED OTHERWISE.
- THIS DRAWING IS TO BE READ IN
   CONJUNCTION WITH OTHER LAYOUT
   DRAWINGS.
- 3. CONCRETE CLASS:

  BASES AND BEAMS = 25/20
  LEAN CONCRETE = 15/20

# LEGEND:

GL - FINISHED GROUND LEVEL





KISUMU WATER AND SANITATION COMPANY





KISUMU WATER SUPPLY
IMPROVEMENT AID ON DELIVERYAOD PROJECT

DETAILED DESIGN

DRAWING T

GENERAL DRAWINGS FIRE HYDRANT DETAILS


Design Master Pl

SCALE:






11100		
Y:	DRAWN BY	:
M.G		G.M
r: J.K	DATE:	DEC. 2024
A3 SIZE:	SHEET No:	1 OF 1
KSM/SD/05		REV.

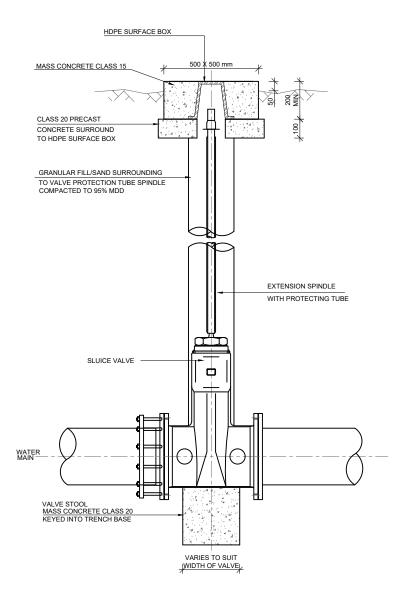

SECTION A - A

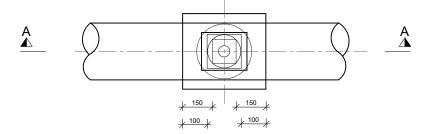

**PLAN VIEW** 

# NOTES:

1. ALL DIMENSIONS ARE IN MILLIMETRES UNLESS STATED OTHERWISE.

REV	DESCRIPTION	DATE



KISUMU WATER AND SANITATION COMPANY





KISUMU WATER SUPPLY
IMPROVEMENT AID ON DELIVERYAOD PROJECT


DETAILED DESIGN

GENERAL DRAWINGS VALVE SURFACE BOX






DESIGNED	BY:	DRAWN BY	r:
	M.G		G.M
CHECKED	BY:	DATE:	
	J.K	D7 (12)	DEC. 2024
SCALE:	A3 SIZE:	SHEET No:	1 OF 1
DRG No:	KSM/SD/0	3	REV.

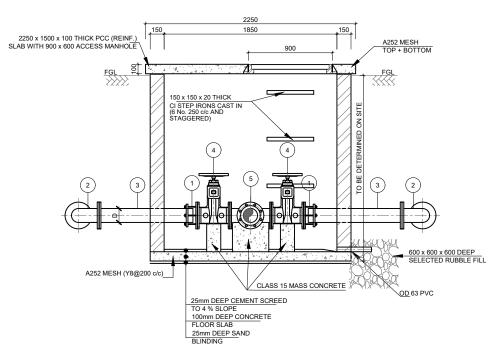


# $\frac{\text{SECTION A-A}}{\text{\tiny SCALE 1:20}}$

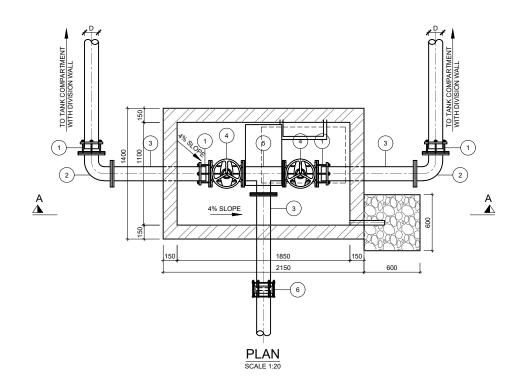


# SCHEDULE OF PIPEWORK & FITTINGS

ITEM	DESCRIPTION	DIAMETER	No.
1.	FLANGE ADAPTOR	D	4
2.	DOUBLE FLANGED 90° BEND	D	2
3.	SINGLE FLANGED PIPE PIECE L = 1000	D	3
4.	DOUBLE FLANGED SLUICE VALVE	D	2
5.	ALL FLANGED TEE	D	1
6.	COUPLINGS TO SUIT WATER MAIN SIZE AND MATERIAL	D	1

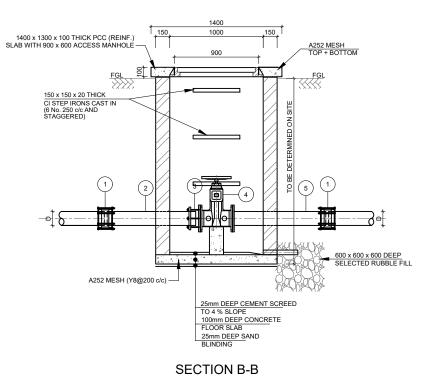

SCALE 1:20

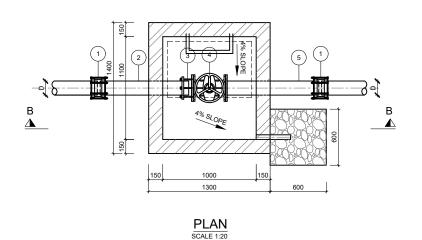

# SCHEDULE OF PIPEWORK & FITTINGS

ITEM	DESCRIPTION	DIAMETER	No.
1.	COUPLINGS TO SUIT WATER MAIN SIZE AND MATERIAL	D	2
2.	PLAIN ENDED PIPE PIECE, L = 1000	D	1
3.	FLANGE ADAPTOR	D	1
4.	DOUBLE FLANGED SLUICE VALVE	D	1
5.	SINGLE FLANGED PIPE PIECE, L = 1000	D	1

# NOTES:

- ALL DIMENSIONS ARE IN MILLIMETERS
   UNLESS OTHERWISE STATED.
- THIS DRAWING IS TO BE READ IN
   CONJUNCTION WITH OTHER LAYOUT
   DRAWINGS.

# LEGEND:

GL FINISHED GROUND LEVEL





KISUMU WATER AND SANITATION COMPANY





KISUMU WATER SUPPLY
IMPROVEMENT AID ON DELIVERYAOD PROJECT

DETAILED DESIGN

DRAWING TITL

GENERAL DRAWINGS VALVE CHAMBER DETAILS

CONSULTANT



Room 12, P.O Box 584 Nairobi, Kenya WITH


Gauff
Consultants
Africa

Chalbi Drive 3734, Lavington,
P.O. Box 49817-00100 Nairobi,
Kenya


DRAWN BY:


DRAWN BY:
G.M

DESIGNED BY:	DRAWN BY:	
M.G	G.M	
CHECKED BY: J.K	DATE: DEC. 2024	
SCALE: A3 SIZE:	SHEET No: 1 OF 1	
DRG No: KSM/SD/0	7 REV.	

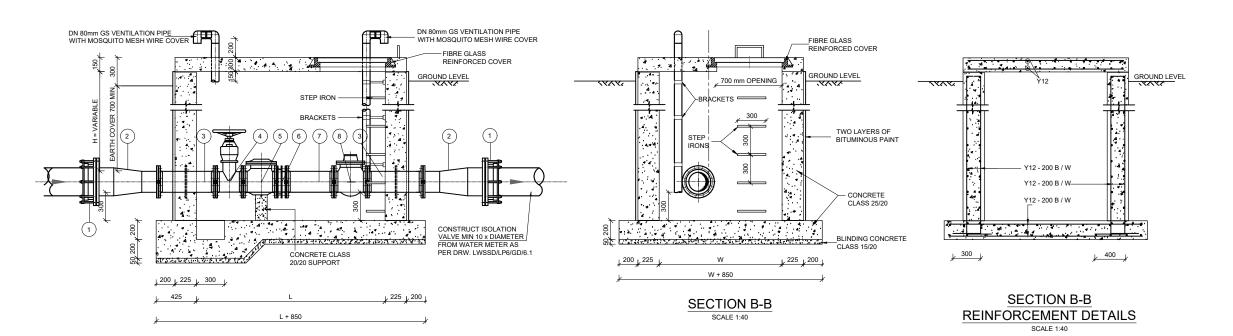

## **SECTION A-A** SCALE 1:40

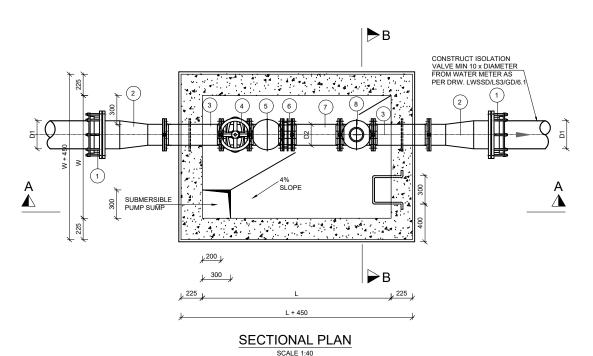

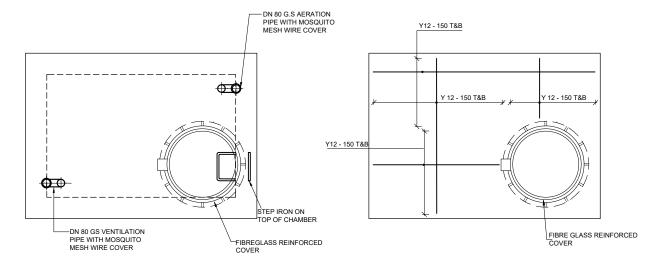

# **ROOF PLAN COVER SLAB WITH MANHOLE COVER**

# **COVER SLAB** REINFORCEMENT DETAILS

# SCHEDULE OF PIPEWORK & FITTINGS

ITEM No.	DESCRIPTION	DIAMETER	QTY
1	FLEXIBLE FLANGE ADAPTOR TO SUIT EXISTING PIPE MATERIAL	D1	2
2	DOUBLE FLANGED CONCENTRIC TAPER	D1/D2	2
3	DOUBLE FLANGED PIPE WITH PUDDLE FLANGE LENGTH = 600mm or 3 x D2 When D2 > 200mm	D2	2
4	DOUBLE FLANGED GATE VALVE HAND WHEEL OPERATED	D2	1
5	STRAINER	D2	1
6	DISMANTLING PIECE	D2	1
7	DOUBLE FLANGED PIPE LENGTH = 5 x D2	D2	1
8	BULK WATER METER	D2	1

 
# DIA. VARIES

D1	D2	
80	50	
100	80	
150	100	
200	150	
250	200	
300	250	
350	300	
	80 100 150 200 250 300	80 50 100 80 150 100 200 150 250 200 300 250

METER SIZE	L mm	W mm
300	4600	1500
250	3500	1000
200	3170	1000
150	2630	1000
100	2100	1000
80	1870	1000
50	1560	1000

# G.S. EQUAL ELBOW 80 mm 90° TO B.S. 1740 80 mm G.S. NIPPLE PLASTIC MOSQUITO GAUGE FIXED WITH CLAMP

DETAILS OF AIR VENT IN CHAMBER



100, 300 100

**DETAILS OF MS STEPS** 

SCALE 1:40

TURBINE METER (WOLTMAN TYPE)

## NOTES:

- HEIGHT OF THE CHAMBER "H" DEPENDS ON PIPE DEPTH. DIMENSION "H" TO BE DETERMINED BY THE CONTRACTOR ON THE SITE AND APPROVED BY THE ENGINEE
- DIMENSIONS "L" AND "W" DEPENDS ON PIPE DIAMETER. DIMENSIONS "L" AND "W" TO BE DETERMINED BY THE CONTRACTOR ON THE SITE AND APPROVED BY THE ENGINEER.
  - PIPE WORK AND VALVE SUPPORT TO BE CONSTRUCTED AS INSTRUCTED BY THE ENGINEER.
- ALL DIMENSIONS ARE IN MILLIMETRES UNLESS STATED OTHERWISE.
- PROVIDE MARKER POSTS FOR FITTINGS AS PER STANDARD DRAWINGS.

NOMINAL DIAMETER

GALVANISED STEEL

T&B TOP & BOTTOM

METAL SHEET



KISUMU WATER AND SANITATION COMPANY



**KFW** 


KISUMU WATER SUPPLY IMPROVEMENT AID ON DELIVERY-AOD PROJECT


DETAILED DESIGN

GENERAL DRAWINGS BULK METER CHAMBER TURBINE METER (WOLTMAN TYPE)

KSM/SD/08

G.M DEC. 2024 1 OF 1

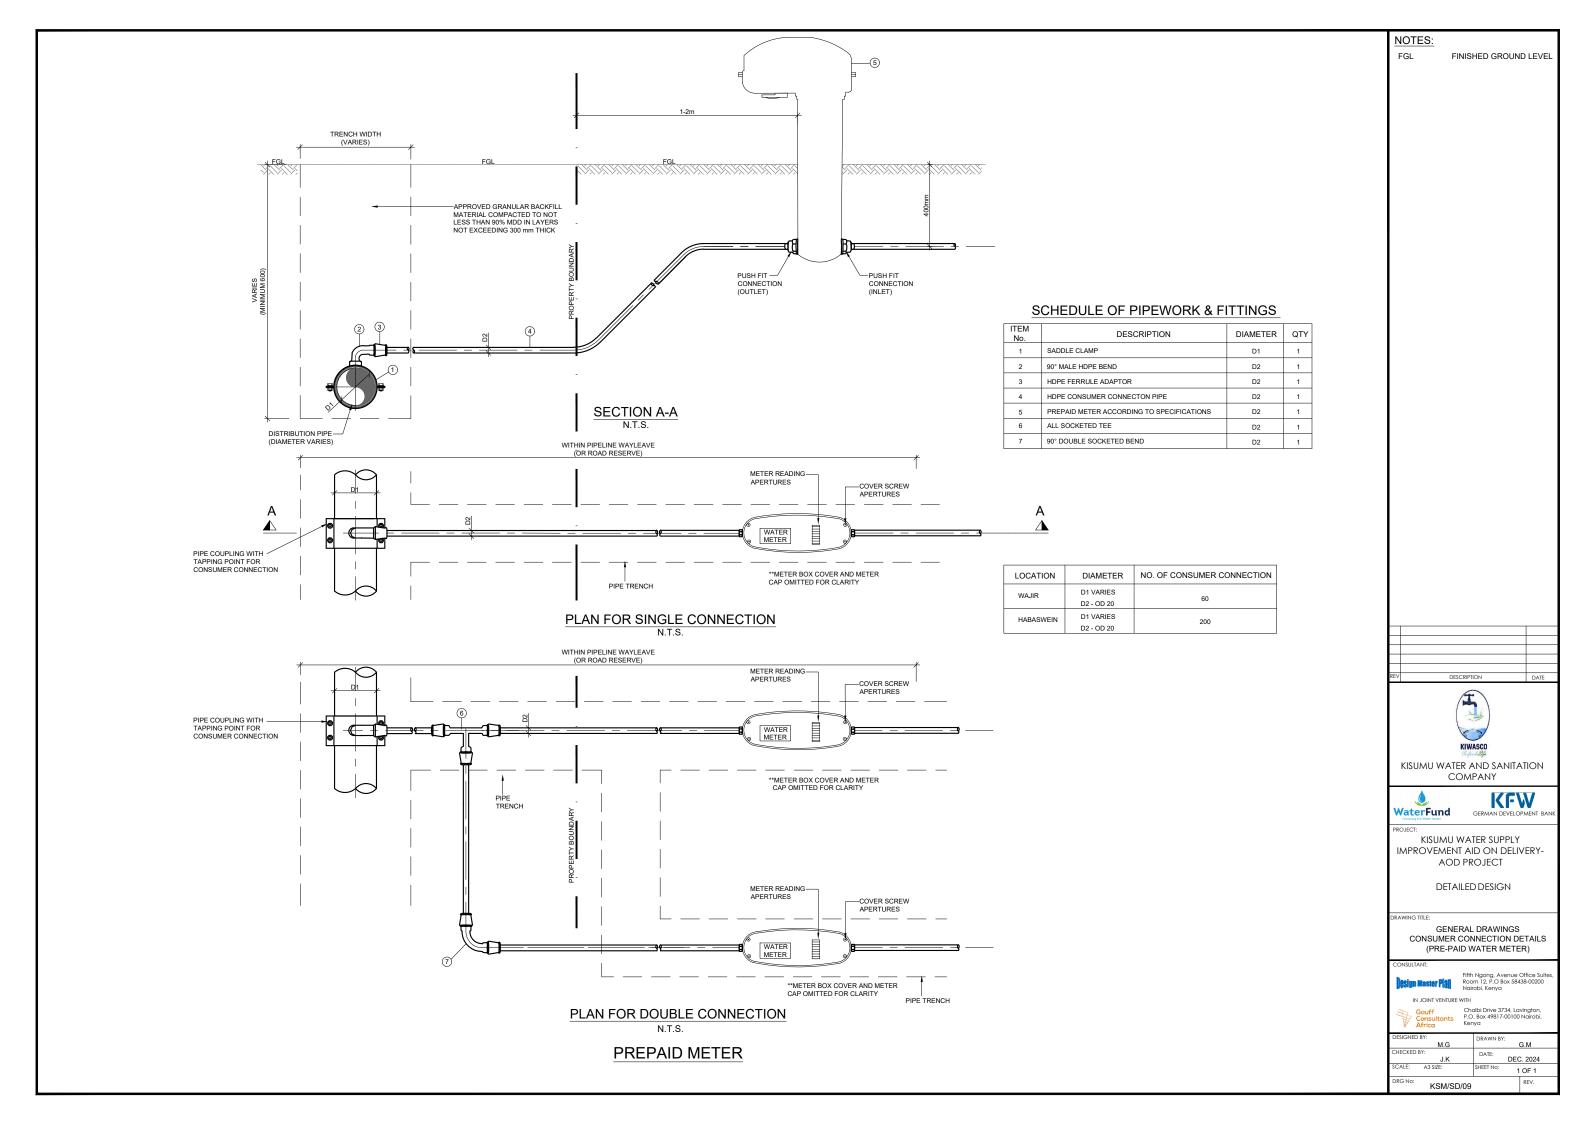

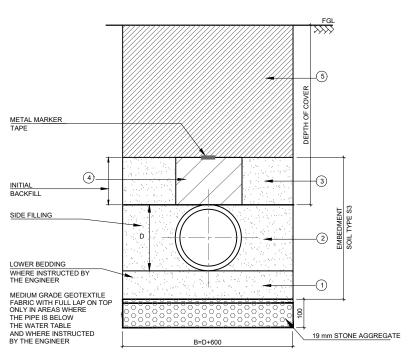


# TYPICAL TRENCH EXCAVATION AND BACKFILLING FOR PE/uPVC PIPES

SCALE N.T.S

# SURFACE(TAMAC,CONCRETE. PARITY BRICKS AS PER ORIGINAL) 150 mm GRADED CRUSHED STONEBASE COMPACTED TO 95 % MOD AASHTO (TYPE S2) 125 mm SUB-BASE COMPACTED TO 97 % MOD AASHTO (MIN UCS 1.5 MPa) (TYPE S1) 125 mm SUB-BASE COMPACTED 97 % MOD AASHTO (MIN UCS 1.5 MPa) (TYPE S1) 170 ms SUB-BASE COMPACTED 170 ms

# PIPE PROTECTION AT SURFACED ROAD CROSSING

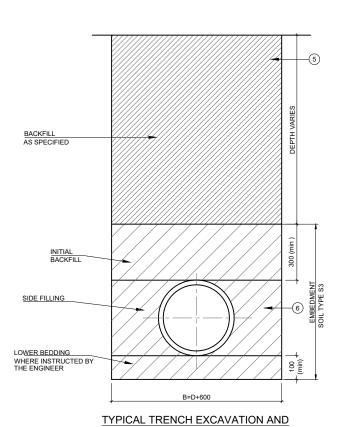

**BACKFILLING FOR FERROUS PIPES** 

SCALE N.T.S

B+300

150

150

A 193 MESH CENTRALLY PLACED

SECTION THROUGH SPREADER BEAM

SCALE N.T.S

# PLAN-LOAD SPREADER BEAM (PCC) SCALE N.T.S


# NOTE

INSTEAD OF A CONCRETE SPREADER BEAM, A CONCRETE OR STEEL PIPE WITH SUFFICIENT INTERNAL BORE TO FACILITATE INSERTION OF PIPES SHOULD BE USED IF INSTRUCTED BY THE ENGINEER.

## TYPICAL TRENCH WIDTHS FOR PIPES

NOMINAL DIAMETER D ( mm )	80	100	160	200	250	300	500
WIDTH OF TRENCH B ( m )	0.70	0.70	0.76	0.80	0.85	0.90	1.10

B = D + 0.6 m (LIMHTED TO A MINIMUM OF 0.6 m)

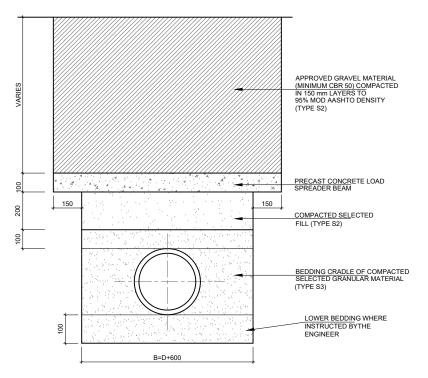

# PIPE PROTECTION AT UNSURFACED ROAD CROSSING

SCALE N.T.S

# LEGEND:

- D PIPE OUTSIDE DIAMETER
- B TRENCH WIDTH (SEE TABLE)
- LOWER BEDDING COMPRISING OF APPROVED GRANULAR BEDDING MATERIAL (SAND)
   COMPACTED TO 90 % MPD IN 50 mm LAYERS TO A THICKNESS OF 100 mm (min.)
   OR AS DIRECTED BY THE ENGINEER'S REPRESENTATIVE.
- APPROVED GRANULAR BEDDING MATERIAL TYPE S3 COMPACTED IN LAYERS AS
   PER NOTE 2. CAREFUL TAMPING ON EITHER SIDE OF THE PIPE SHOULD BE
   MAINTAINED TO ENSURE EQUAL PRESSURE ON BOTH SIDES OF THE PIPE.
- (3) APPROVED GRANULAR BEDDING MATERIAL TYPE S3 COMPACTED IN SHALLOW LAYERS TO A MAXIMUM OF 150 mm THICK.
- 4 AS IN 3 ABOVE, BUT EXCESSIVE TAMPING TO BE AVOIDED.
- NORMAL BACKFILL MATERIAL PROPERLY RAMMED IN LAYERS. NOT EXCEEDING 150 mm THICK.
- APPROVED GRANULAR BACKFILL MATERIAL COMPACTED TO 90% MPD IN LAYERS
   AS PER NOTE 2.

# PRECAST CONCRETE LOAD SPREADER BEAM

# TABLE 1: MATERIAL DESCRIPTION CHART

SOIL TYPE DESCRIPTION		GROUP SYMBOL
S1	GRAVEL - SINGLE SIZE	GW
S2	GRAVEL - GRADED	GP
S3	SAND AND COARSE GRAINED SOILS WITH LESS THAN 12% FINES.	GF

#### TABLE 2 : COMPACTION CHART GUIDE

	SOIL TYPE	COMPACTION METHOD		
% MPD		THICKNESS OF	No. OF	
		LAYER (max.)	PASSES	
90	S1 S2 S3	150 150 50	1 2 2	

#### NOTES

- MINIMUM TRENCH WIDTH TO BE NORMAL
- PIPE DIAMETER PLUS 600 mm.

  2. THE LOWER BEDDING AND THE SIDE FILL SHALL BE COMPACTED IN LAYERS WHOSE DEPTH SHALL NOT EXCEED 50 mm NOR HAL THE NOMINAL PIPE DIAMETER WHICHEVER IT THE LESSED
  - THE LESSER.
    IN GENERAL, THE METHOD OF ATTAINING
    THE REQUIRED COMPACTION WILL BE
    ASCERTAINED AS FOLLOWS:
    (i) THE ENGINEER'S REPRESENTATIVE WILL
    IDENTIFY, CLASSIFY AND AGREE THE SOIL
    TYPE OF EMBEDIMENT MATERIAL AVAILABLE
- (i) THE ENGINEER'S REPRESENTATIVE WILL IDENTIFY, CLASSIFY AND AGREE THE SOIL TYPE OF EMBEDMENT MATERIAL AVAILABLE FROM THE TRENCH. (ii) THE SITE SOIL TYPE WILL BE COMPARED WITH THOSE ON THE MATERIAL DESCRIPTION CHART [ SEE TABLE 1 ] (iii) THE COMPACTION METHOD REQUIRED IS THEN SELECTED FROM THE COMPACTION CHART FOR THE APPROPRIATE SOIL TYPE
- THEN SELECTED FROM THE COMPACTION CHART FOR THE APPROPRIATE SOIL TYPE AND CLASS OF EMBEDMENT [ SEE TABLE 2 ]

  4. NOT ALL SOILS ARE GIVEN IN TABLE 1. IT SHOULD BE NOTED THAT:

  (i) FINED GRAINED SOILS WITH HIGH PLASTICITY MAY NOT BE USED AS BACKFILL.

  (ii) FINED GRAINED SOILS WITH LOW PLASTICITY MAY BE CONDEMNED FOR USE AS BACKFILL IF THE CONTRACTOR HAS DIFFICULTY IN ATTAINING THE REQUIRED
- AS BACKFILL IF THE CONTRACTOR HAS DIFFICULTY IN ATTAINING THE REQUIRED COMPACTION.

  5. WHERE SITE MATERIAL IS CONDEMNED, IMPORTED MATERIAL IS LODE THIS SHALL BE A WELL GRADED SOIL FROM FINES UPTO 20 mm GRAVEL OR AS APPROVED BY THE ENGINEER'S REPRESENTATIVE.
- THE ENGINEER'S REPRESENTATIVE.
  6. WHERE SOME DOUBT EXISTS AS TO THE
  COMPACTIBILITY OF THE SOIL AS DEFINED
  ABOVE, RECOURSE SHALL BE MADE TO THE
  MODIFIED PROCTOR DENSITY TEST. THE SITE
  AND LABORATORY TESTS SHALL BE CARRIEL
  OUT TO TESTS 14 B AND 12 RESPECTIVELY TO
  SSPN 601
- SSRY 001.

  JESTONES OR ROCK ARE PRESENT,
  IMPORTED BEDDING MATERIAL OF MIN.
  150 mm THICK SHALL BE REQUIRED AS
  APPROVED BY THE ENGINEER'S
  REPRESENTATIVE. AT DESIGNATED ROAD
  CROSSINGS, THE BEDDING SHALL HAVE A
  MINIMUM THICKNESS OF 150 mm.

  THE BACKFILL SHALL BE PLACED IN LAYERS
- THE BACKFILL SHALL BE PLACED IN LAYERS
  AS DEFINED ABOVE. EACH LAYERS SHALL BE
  RAMMED WITH A SMALL VIBRATORY RAMMER
  THE LIKELY REQUIRED NUMBER OF PASSES
  OF THE RAMMER IS GIVEN IN TABLE 2.
  HOWEVER 90% MPD SHALL BE ACHIEVED AT
  ALL TIMES.
- ALL TIMES.

  9. ONLY WHEN THERE IS 300 mm COVER OVER THE PIPE MAY HEAVIER COMPACTING EQUIPMENT BE USED. THE REMAINDER OF THE BACKFILL SHALL BE SUITABLY COMPACTED IN KEEPING WITH THE REINSTATEMENT OF THE GROUND TO BE CARRIED OUT. THIS SHALL BE AGREED UPON WITH THE ENGINEER'S REPRESENTATIVE.





KISUMU WATER AND SANITATION COMPANY





: KISUMU WATER SUPPLY

IMPROVEMENT AID ON DELIVERY-AOD PROJECT

DETAILE DESIGN

RAWING TITLE:


GENERAL DRAWINGS PIPE BEDDING DETAILS

Design Master P(a



halbi Drive 3734, Lavington, O. Box 49817-00100 Nairobi, enya


DESIGNED BY:	DRAWN BY	:
M.G		G.M
CHECKED BY: J.K	DATE:	DEC. 2024
SCALE: A3 SIZE:	SHEET No:	1 OF 1
DRG No: KSM/SD/10	)	REV.

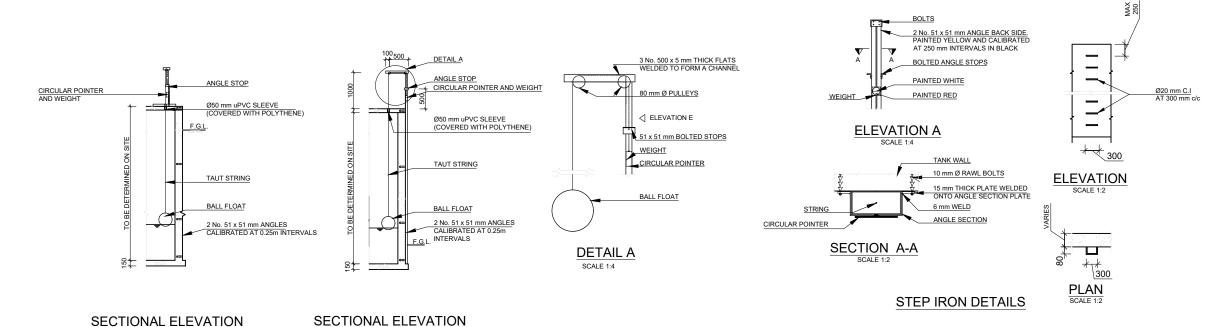


TANK LEVEL INDICATOR

**DETAILS OF G.M.S LADDER** 

SCALE 1:4

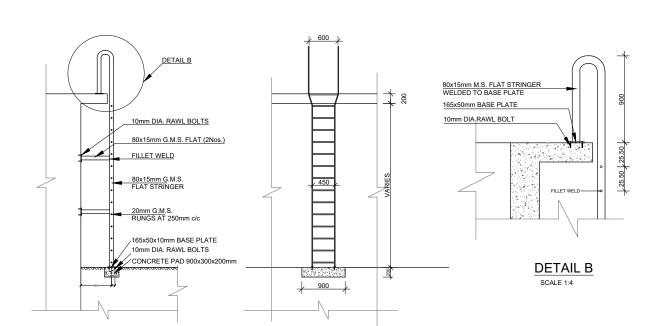

SCALE 1:4

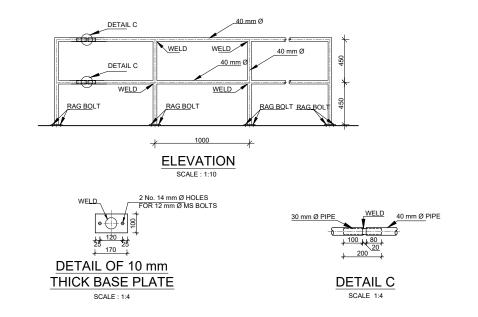

**DETAILS OF HANDRAIL** 

# NOTES:

ALL DIMENSIONS ARE IN MILLIMETRES UNLESS STATED OTHERWISE.





KISUMU WATER AND SANITATION COMPANY





KISUMU WATER SUPPLY IMPROVEMENT AID ON DELIVERY-

AOD PROJECT DETAILED DESIGN


GENERAL DRAWINGS TANK LEVEL INDICATOR , LADDER, HANDRAIL AND STEP IRON DETAILS



DEC. 2024
SHEET No: KSM/SD/11

# 6000 CARRIAGEWAY EXISTING GROUND PROFILE TOP OF FILL: COMPACTED PRIOR TO APPLYING GRAVEL TO 100% AASHTO T99 200 mm GRAVEL WEARING COURSE COMPACTED TO 95% MDD AASHTO T180 77.77.77.77 EXISTING GROUND TO BE SHAPED AND COMPACTED TO 93% AASHTO T99 APPROVED FILL MATERIAL COMPACTED TO 93% AASHTO T99 EXISTING DRAIN (IF PRESENT) TO BE RECONSTRUCTED AS SHOWN

# TYPICAL ACCESS ROAD CROSS SECTION DETAILS

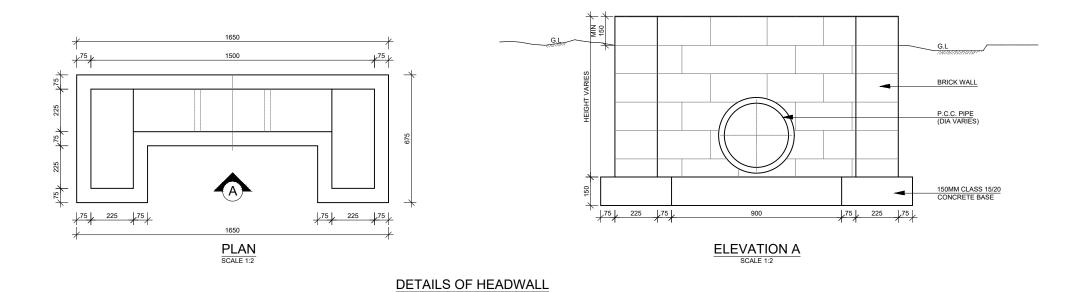

NOTES:

1. ALL DIMENSIONS ARE IN MILLIMETERS UNLESS STATED OTHERWISE

LEGEND:

P.C.C PRE-CAST CONCRETE





KISUMU WATER AND SANITATION COMPANY



KFW

KISUMU WATER SUPPLY
IMPROVEMENT AID ON DELIVERYAOD PROJECT


DETAILED DESIGN

GENERAL DRAWINGS ACCESS ROAD (MURRAM)






DEC. 2024 1 OF 2

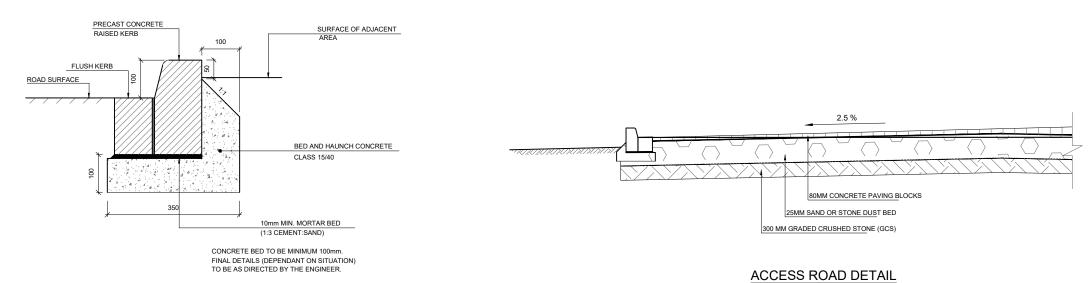

# BEDDING AND HAUNCHING TO PRECAST KERB

SCALE 1:5

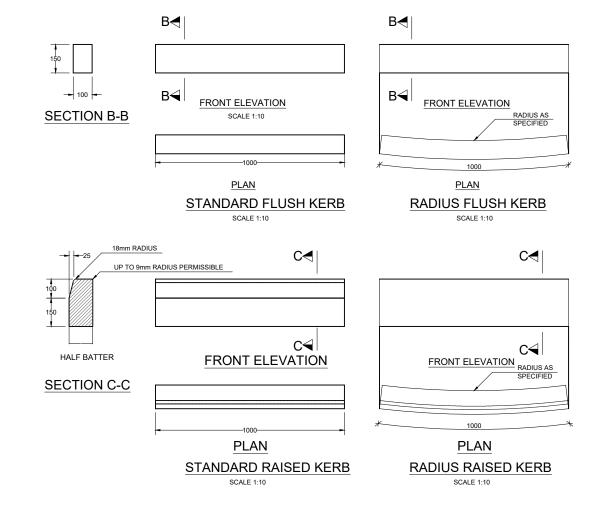

## NOTES:

ALL DIMENSIONS ARE IN MILLLIMETRES
 UNLESS OTHERWISE STATED.

2. GAPS TO BE PROVIDED AT 10-15m INTERVALS TO PASS WATER FROM THE CARRIAGEWAY TO THE DRAINAGE.

ı		
REV	DESCRIPTION	DATE



KISUMU WATER AND SANITATION COMPANY



KFW FRMAN DEVELOPMENT BA

PRO IECT:

KISUMU WATER SUPPLY
IMPROVEMENT AID ON DELIVERYAOD PROJECT

DETAILED DESIGN

DRAWING TIT

GENERAL DRAWINGS ACCESS ROAD CONCRETE PAVING STONES

CONSULT



Fifth Ngong, Avenue Office S Room 12, P.O Box 58438-0020 Nairobi, Kenya





Chalbi Drive 3734, Lavington, P.O. Box 49817-00100 Nairobi, Kenya


DRAWN BY:

G.M

M.G		G.M	
CHECKED BY:	DATE:		
J.K	D7 (12.	DEC. 2024	
SCALE: A3 SIZE:	SHEET No:	2 OF 2	
DRG No:		REV.	

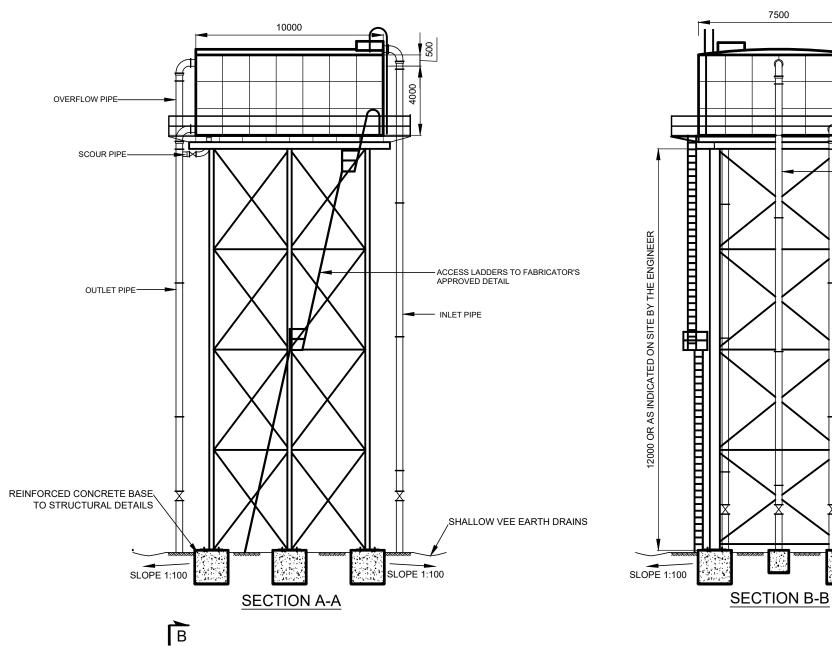

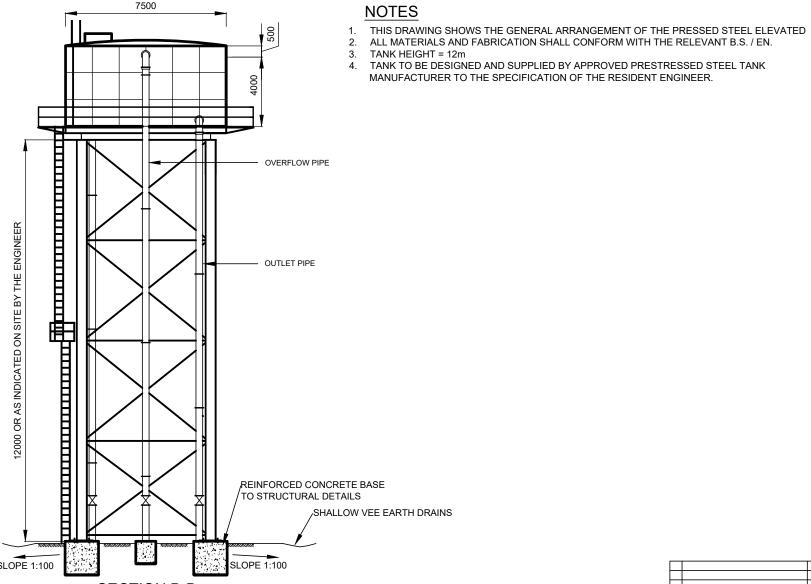

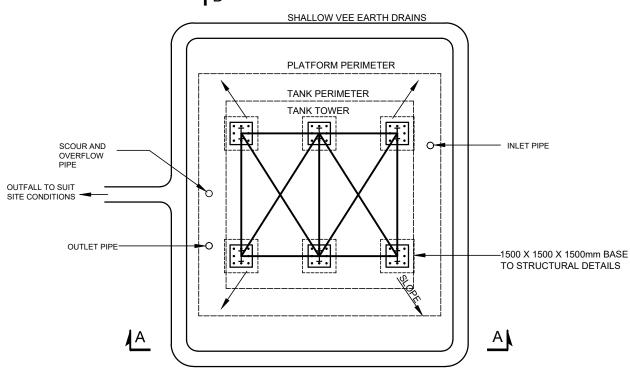

FOUNDATION PLAN

В





KISUMU WATER AND SANITATION COMPANY



KFW

KISUMU WATER SUPPLY IMPROVEMENT AID ON DELIVERY-AOD PROJECT

DETAILED DESIGN

GENERAL DRAWINGS STEEL ELEVATED TANK 300m³ PLAN AND SECTIONS

Gauft Chalbi Drive 3734, Lavington, Consultants Africa P.O. Box 49817-00100 Nairobi, Kenya

1 OF 1